
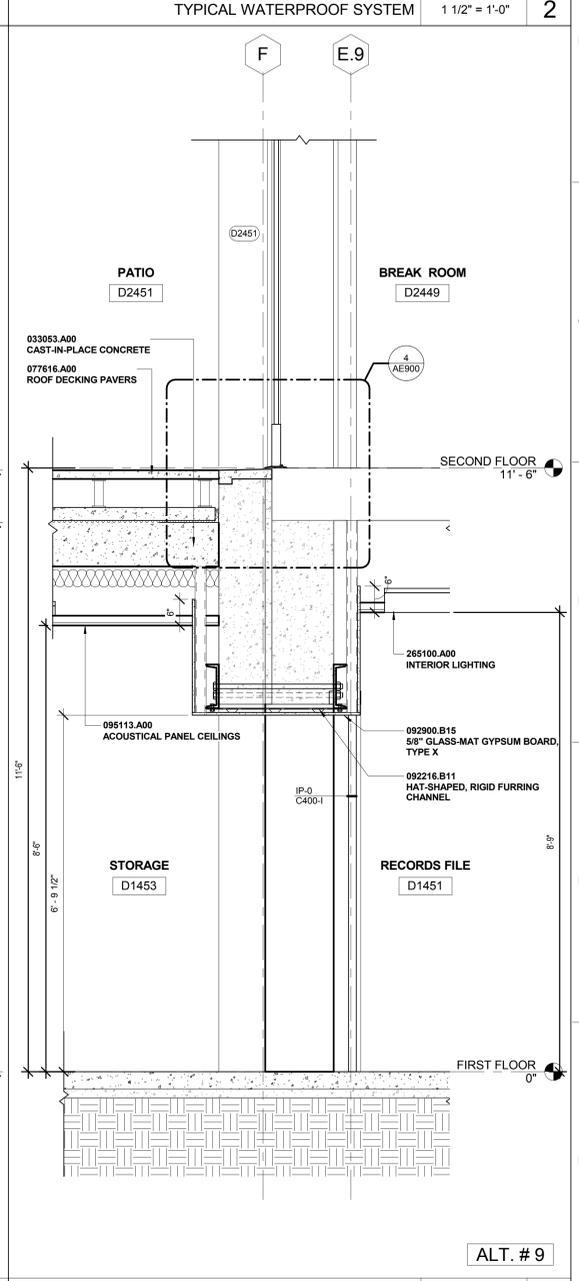
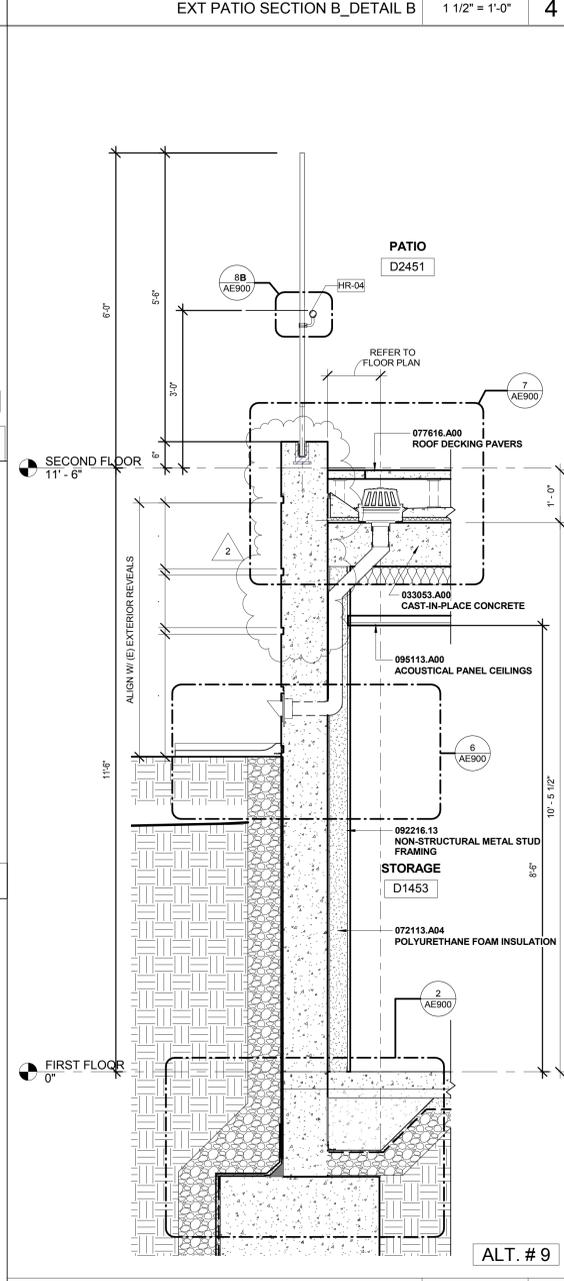
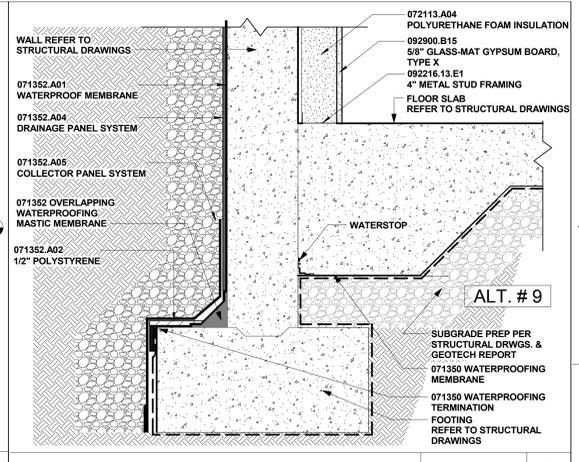
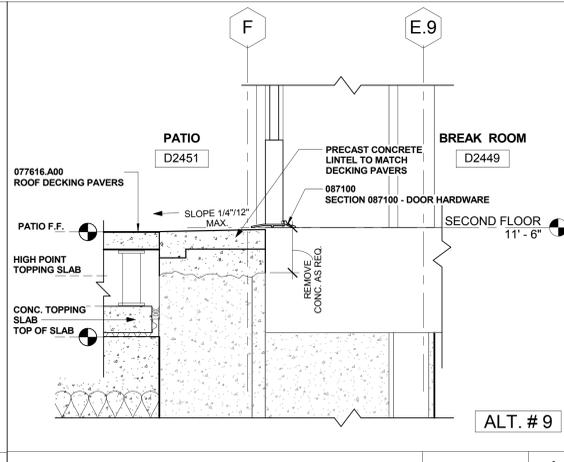
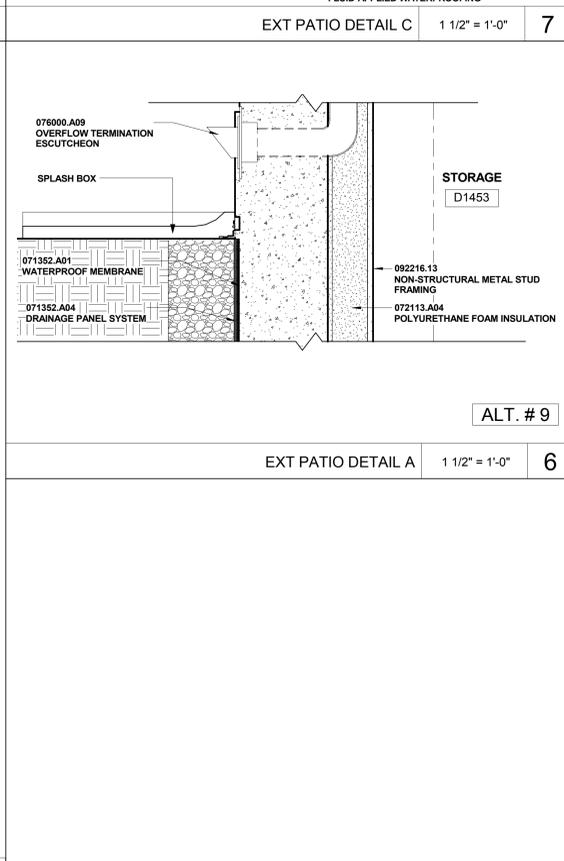
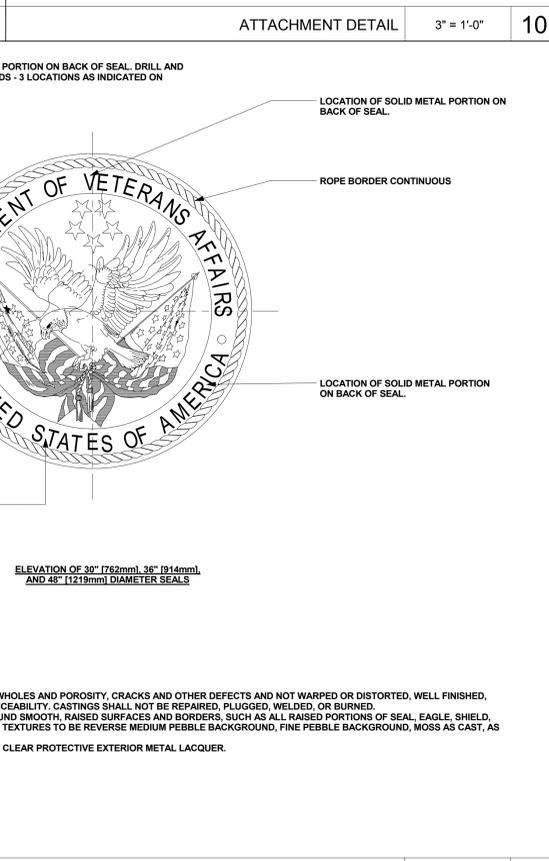
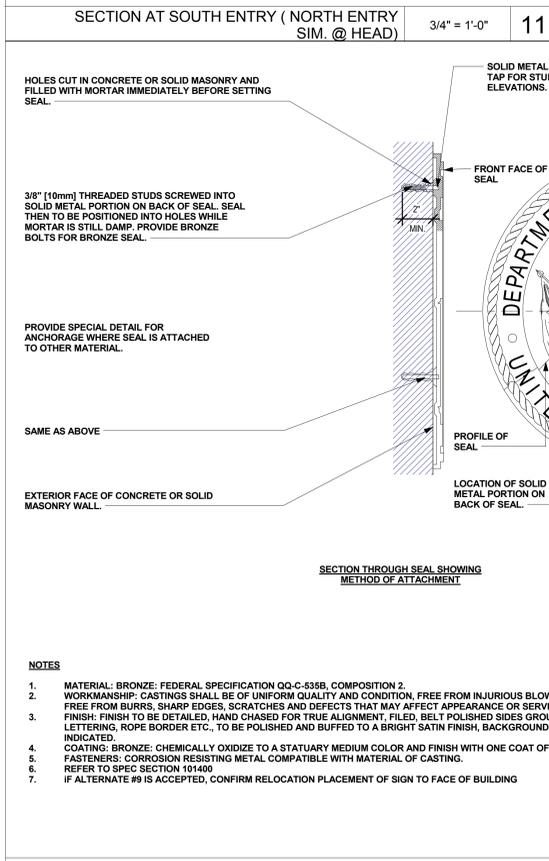
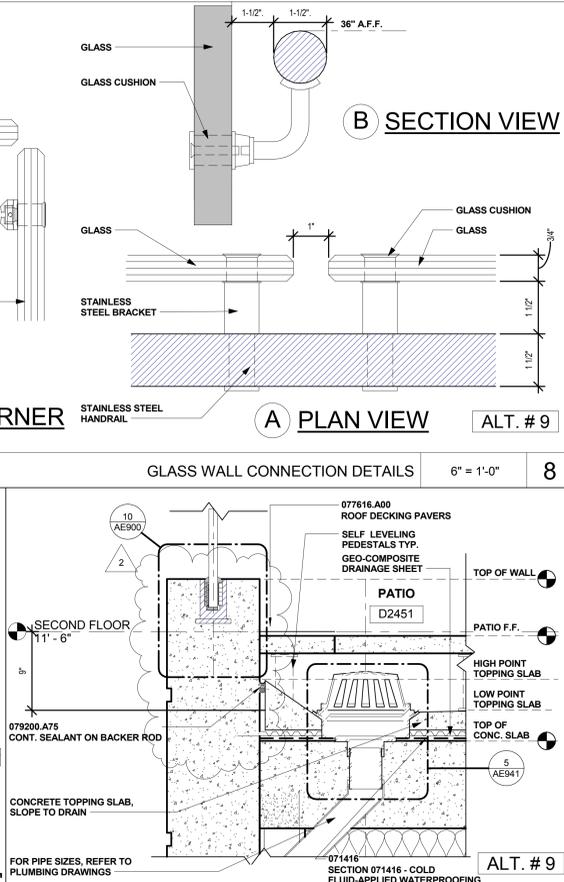
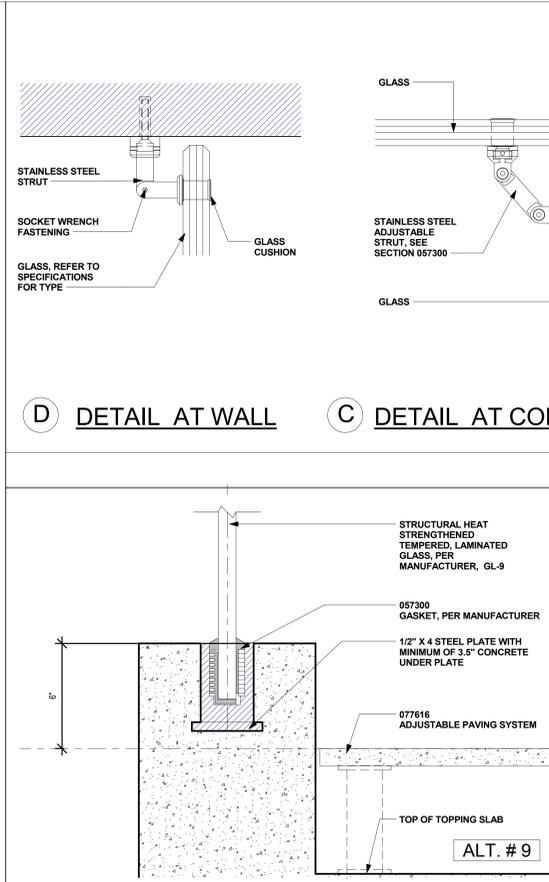


three eighths inch = one foot  
 one eighth inch = one foot  
 one quarter inch = one foot  
 one half inch = one foot  
 one inch = one foot  
 one and one half inch = one foot  
 two inches = one foot  
 three inches = one foot

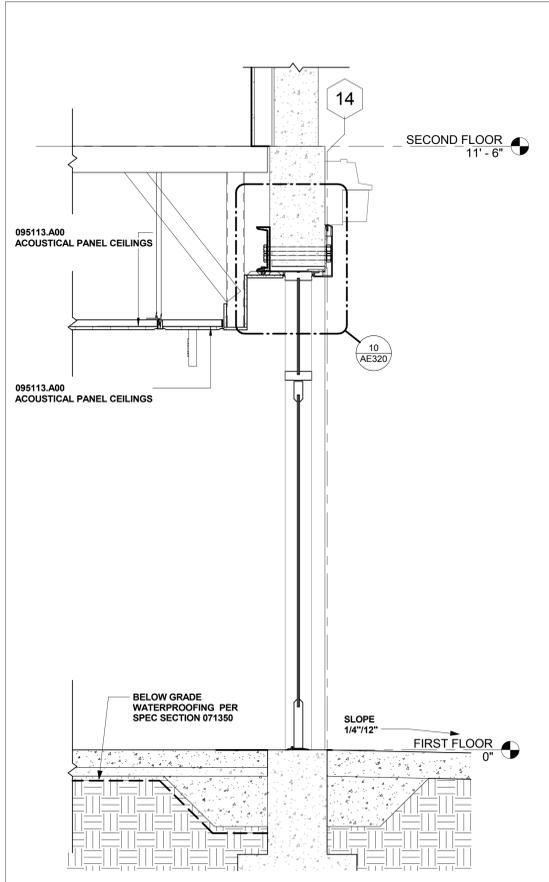

2	Amendment 2	7/9/2012
---	-------------	----------

VA EXTERIOR LOGO 1 1/2" = 1'-0" 9

**Consultants**  
**COLLABORATIVE DESIGN**  
 STUDIO architecture of experience and place  
 www.collaborativedesignstudio.com  
 T 775.348.7777 F 775.348.0904  
 9444 DOUBLE R BLVD SUITE B | RENO NV 89521

**Reviewing Agency - Fire Protection**  
**AON**  
 Fire Protection Engineering  
 Aon Fire Protection Engineering Corporation  
 11770 Bernardo Plaza Court | Suite 116 | San Diego, CA 92128  
 T +1.858.673.5845 | F +1.858.673.5849 | www.aonfire.com  
 Fire Protection | Code | Risk | Life Safety | Security

**Architects/Engineers**  
**RBB ARCHITECTS INC**  
 10980 Wilshire Boulevard 917 7th St. 2nd Floor Ste. 3  
 Los Angeles, California Sacramento, California  
 90024-3905 95814  
 Telephone 310 473 3555 Telephone 310 473 3555  
 Facsimile 310 473 3555 Facsimile 310 473 3555  
 www.rbbinc.com www.rbbinc.com

Drawing Title  
 EXTERIOR WALL SECTIONS

Scale  
 As indicated

Approved Project Director

**RBB**

Project Title  
 VA SIERRA NEVADA HEALTHCARE SYSTEM  
 BLDG 1A - SEISMIC CORRECTIONS

Project No.  
 RBB #1013700

VA Contract No.  
 VA261-P-088

Location  
 975 KIRMAN AVE., RENO, NEVADA 89502

Date  
 05/01/2012

Checked  
 RP

Drawn  
 TYC

VA Project No.  
 654-336

Building No.  
 1A

Drawing No.  
 AE900

**Office of Construction and Facilities Management**  
 Department of Veteran Affairs

BID DOCUMENTS