
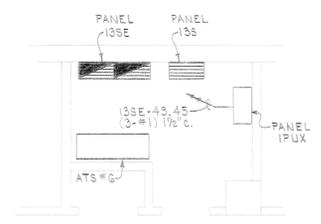



three inches = one foot  
 one and one half inches = one foot  
 one inch = one foot  
 three quarters inch = one foot  
 one half inch = one foot  
 three eighths inch = one foot  
 one quarter inch = one foot  
 one eighth inch = one foot

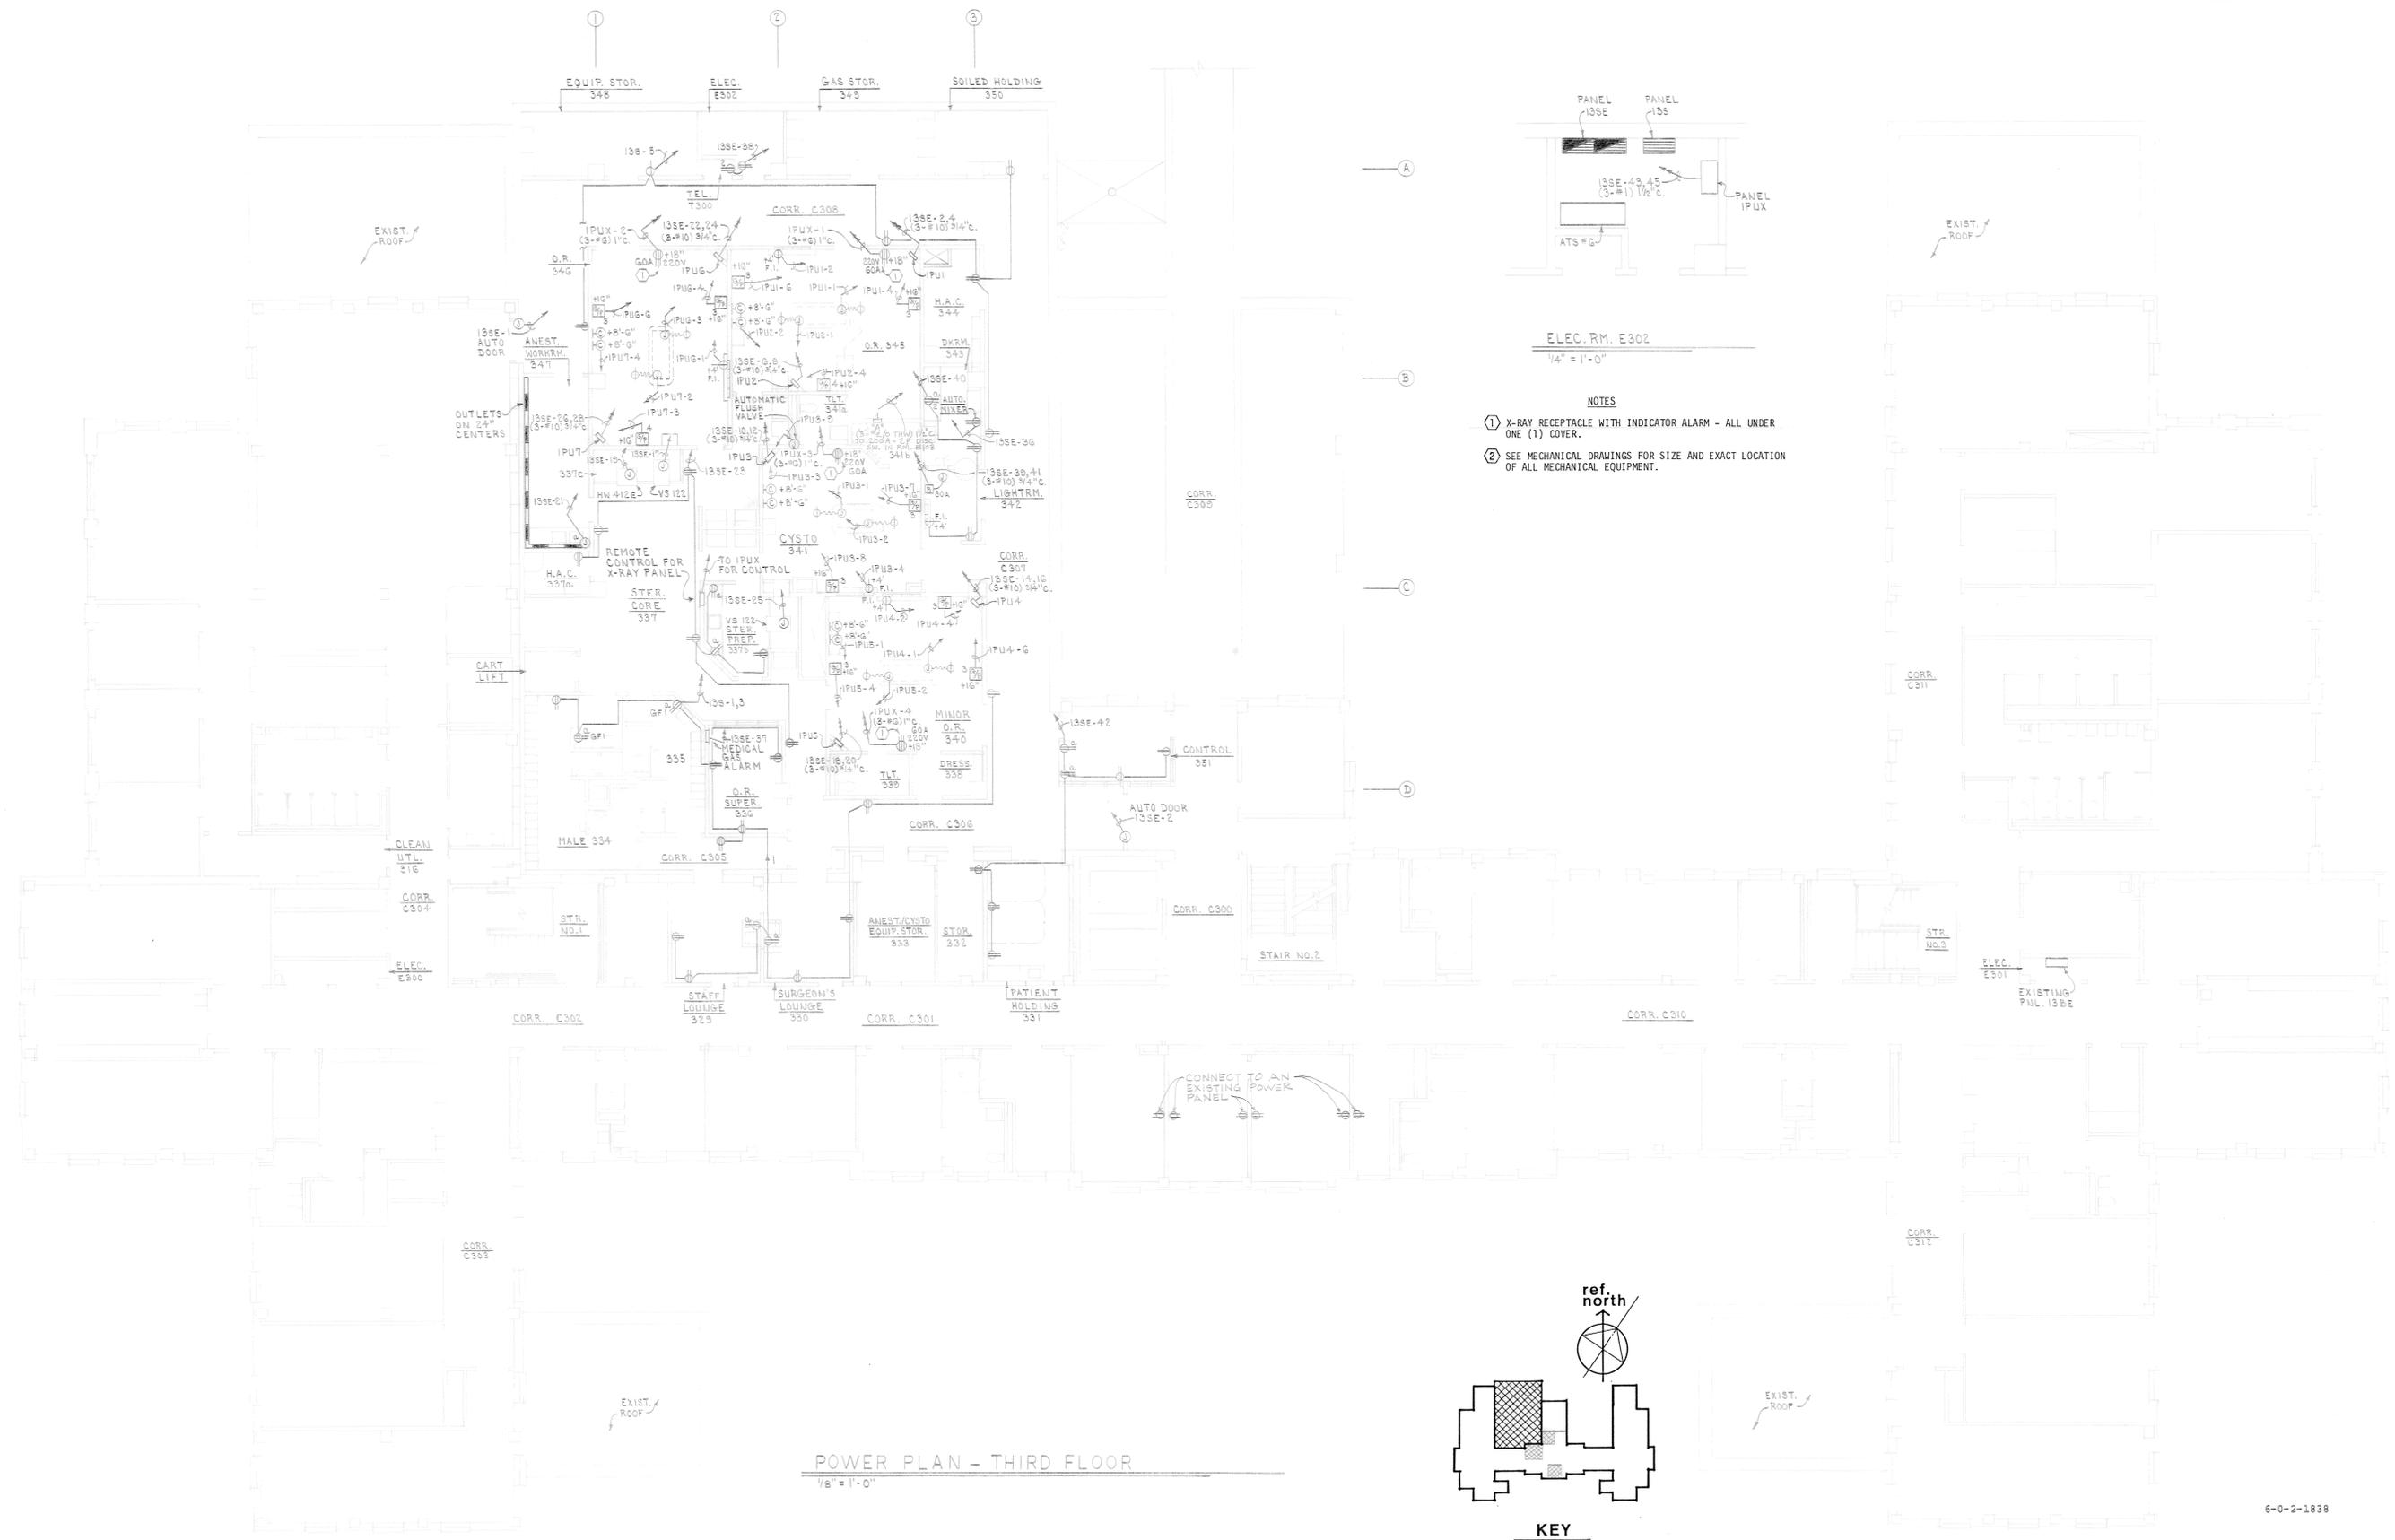

ELEC. RM. E302  
1/4" = 1'-0"

- NOTES
- X-RAY RECEPTACLE WITH INDICATOR ALARM - ALL UNDER ONE (1) COVER.
  - SEE MECHANICAL DRAWINGS FOR SIZE AND EXACT LOCATION OF ALL MECHANICAL EQUIPMENT.

POWER PLAN - THIRD FLOOR  
1/8" = 1'-0"

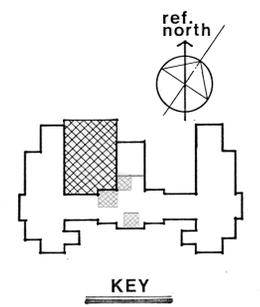

6-0-2-1838

AS-BUILT Revisions Date	Date	<b>LASER KNIGHT HENDRIX &amp; GUEST, P.A.</b> ARCHITECTS • HEALTH CARE PLANNERS 800 FIRST NATIONAL BANK • FORT SMITH, ARKANSAS		Drawing Title POWER PLAN - THIRD FLOOR	Project Title CLINICAL ADDITION	Date OCT. 1, 1981	<b>Veterans Administration</b>
				Approved Project Director 	Drawn A.T.	Building Number 1	
				Checked P.H.	Location VAMC FAYETTEVILLE, ARKANSAS	DRAWING NO. <b>1-E12</b> Dwg. 14 Of 23	