



ROOM FINISH FLOOR PLAN

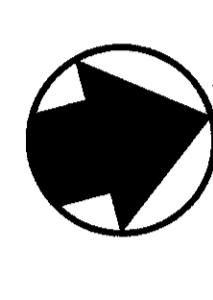


GRAPHIC SCALE: SPACES NUMBER SCALE
0 4 8 16
SCALE: 1/8" = 1'-0"

A9.1 A9.1

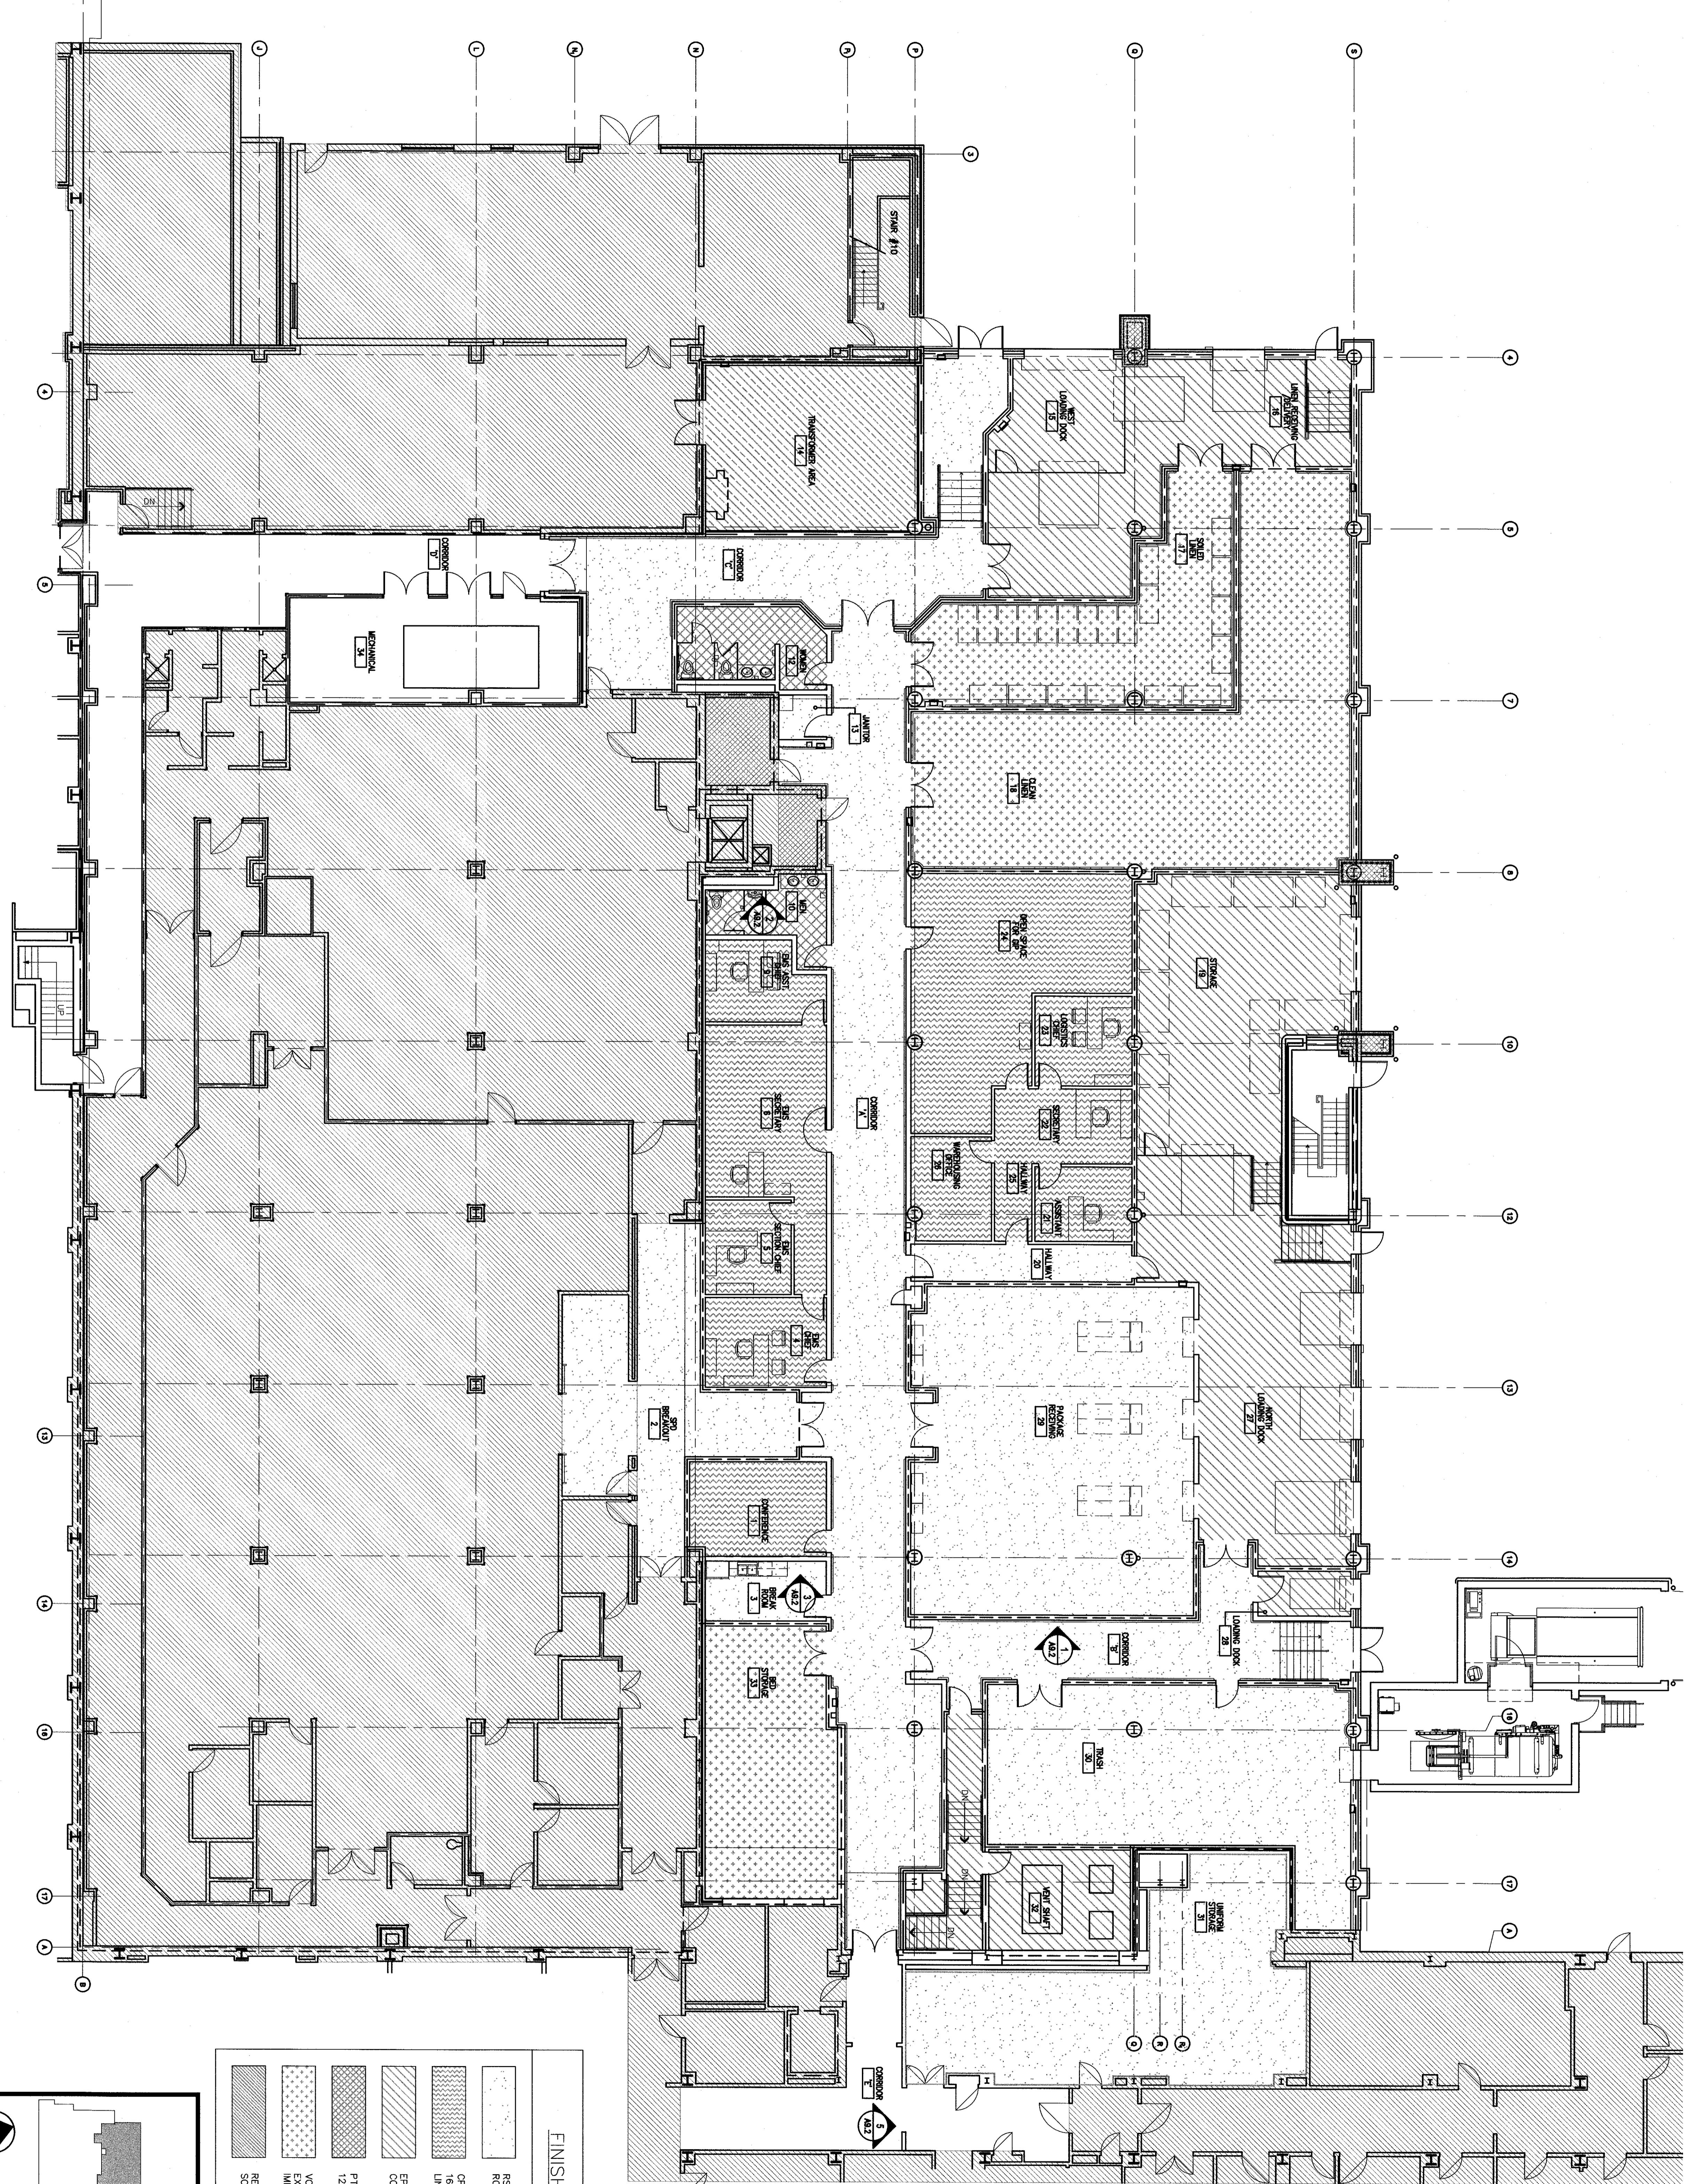

BID DOCUMENTS

FULLY SPRINKLERED BUILDING

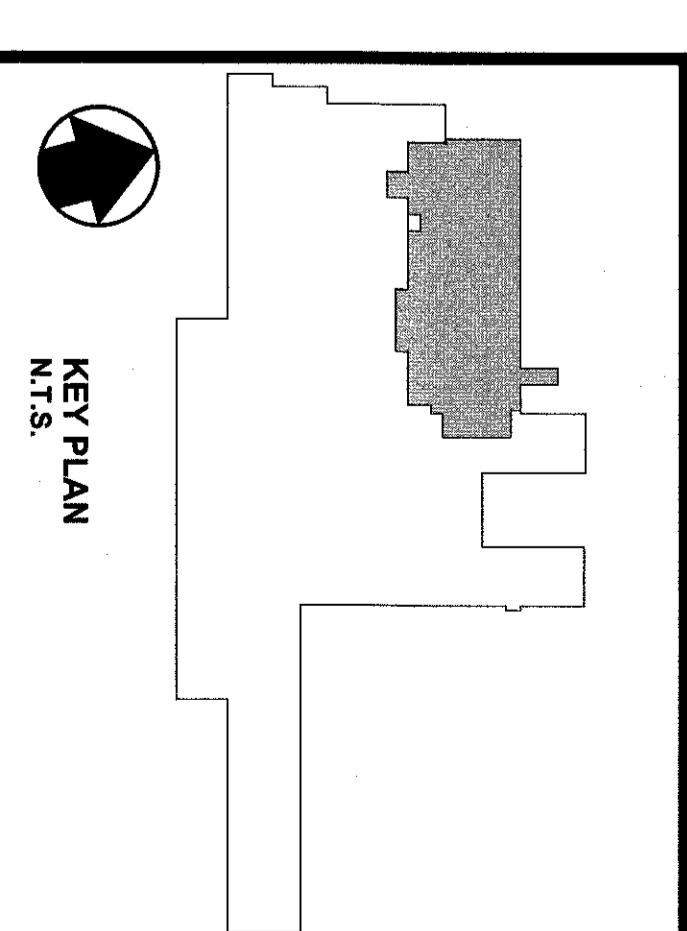

Department of
Veterans Affairs

UPGRADE SPD AND SECURITY DOCK
PROJECT: 646-367
VA PITTSBURGH
HEALTHCARE SYSTEM
UNIVERSITY DRIVE C
PITTSBURGH, PENNSYLVANIA 15240

DATE
7-28-11

KEY PLAN

REF ID:

REVISION:

DATE:

7-28-11

ROOM FINISH FLOOR PLAN

DRAWING NO. A9.1

REV PG. 1

PARADIGM
ENGINEERS AND CONTRACTORS
PO BOX 436223
Louisville, Kentucky 40253
502-359-8511 www.paradigmusa.com

