
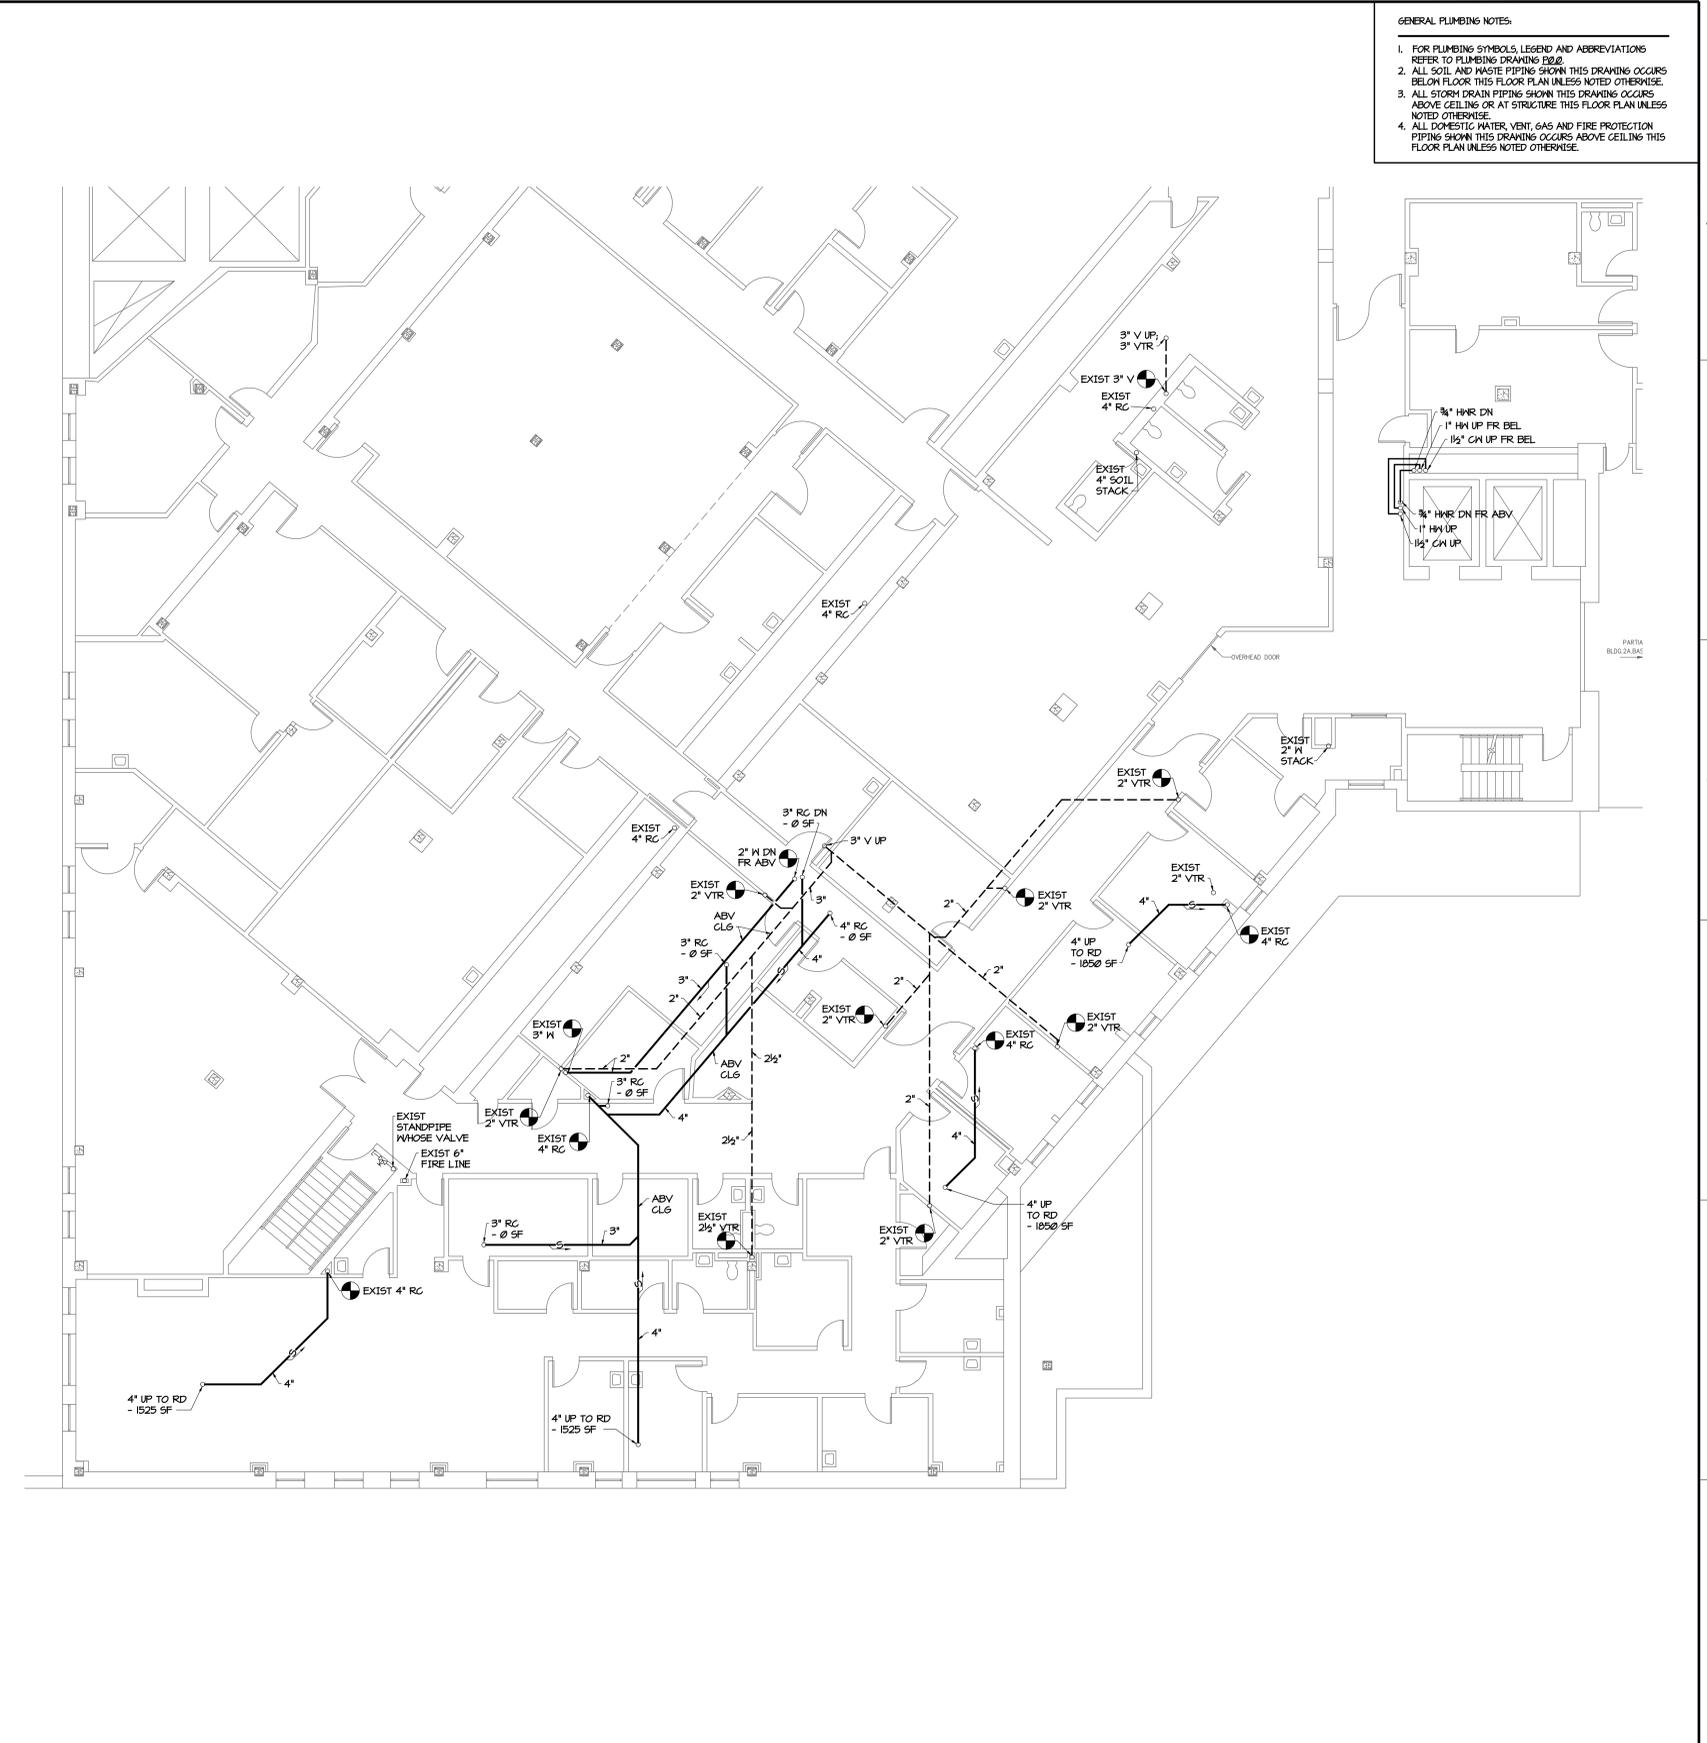


three eighths inch = one foot
 one quarter inch = one foot
 one eighth inch = one foot
 three quarters inch = one foot
 one and one half inches = one foot
 one inch = one foot
 three inches = one foot

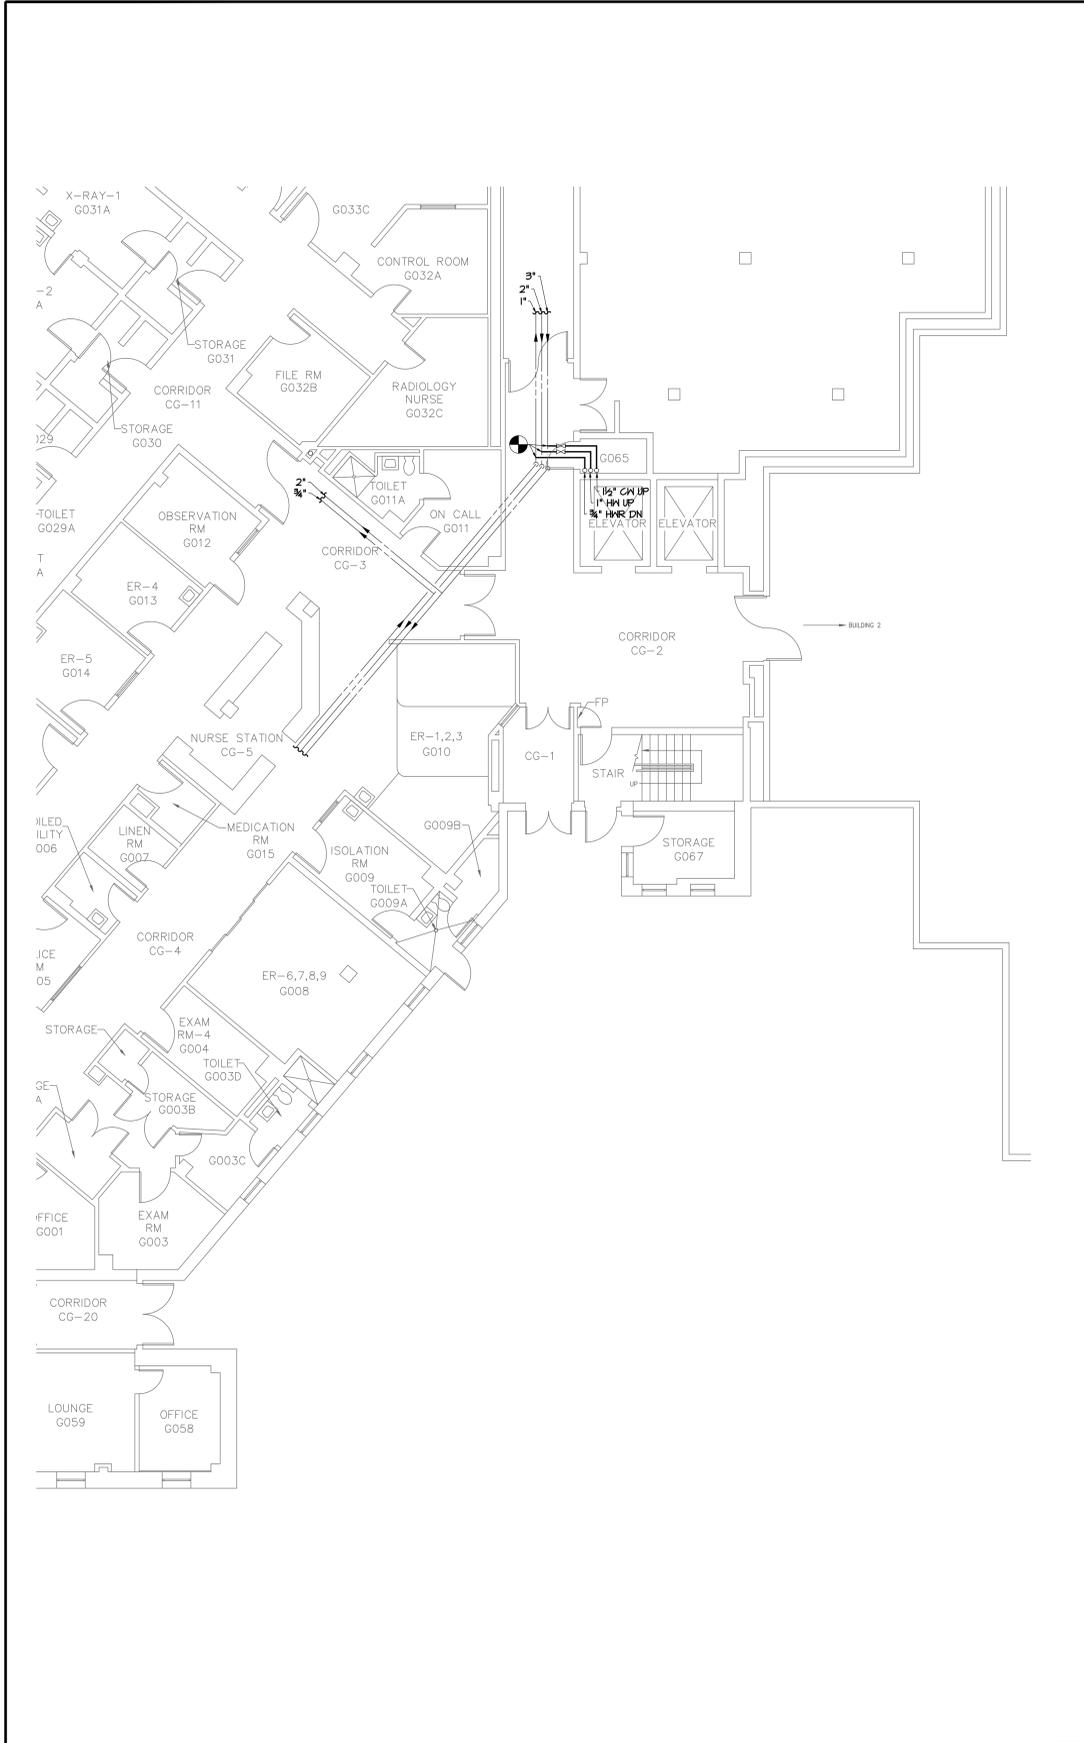

- GENERAL PLUMBING NOTES:**
1. FOR PLUMBING SYMBOLS, LEGEND AND ABBREVIATIONS REFER TO PLUMBING DRAWING E02.
 2. ALL SOIL AND WASTE PIPING SHOWN THIS DRAWING OCCURS BELOW FLOOR THIS FLOOR PLAN UNLESS NOTED OTHERWISE.
 3. ALL STORM DRAIN PIPING SHOWN THIS DRAWING OCCURS ABOVE CEILING OR AT STRUCTURE THIS FLOOR PLAN UNLESS NOTED OTHERWISE.
 4. ALL DOMESTIC WATER, VENT, GAS AND FIRE PROTECTION PIPING SHOWN THIS DRAWING OCCURS ABOVE CEILING THIS FLOOR PLAN UNLESS NOTED OTHERWISE.

PARTIAL EXISTING GROUND FLOOR PLAN - PLUMBING

1/8" = 1'-0"

2 PARTIAL EXISTING FIRST FLOOR PLAN - PLUMBING


1/8" = 1'-0"

Revisions	Date

ARCHITECT/ENGINEERS:

SFCs Architecture Engineering Planning Interiors

SFCs Inc. • 305 South Jefferson Street
 Roanoke, Virginia 24011.2003
 540.344.6664 • Fax 540.343.6925
 www.sfc.com

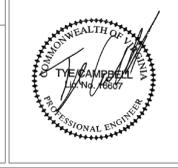

Approved Energy Engineer	Approved Infection Control	Approved Service Chief
CONSTRUCTION DOCUMENTS	Approved Safety Manager	Approved Chief of Staff
	Approved GEMS Coordinator	Approved Associate Director

Drawing Title: PARTIAL GROUND + FIRST FLOOR PLAN - PLUMBING	Project Title: Patient Dining Area CLC VA Medical Center SFCs Commission Number: 6527.00	Project Number: 658-307 Building Number(s): 2/2A	Office of Construction and Facilities Management
	Approved Chief of Facility Management Services	Location: Salem, Virginia	
Approved Medical Center Director	Date: 03/15/12	Checked: -	Drawn: CMO