




45 DEGREE BRANCH TAKEOFF
SCALE: NTS

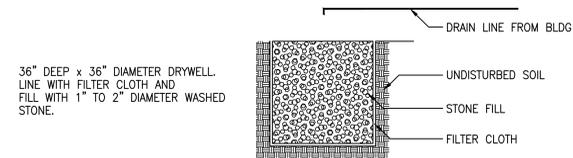

3 DRY WELL DETAIL
M504 NTS

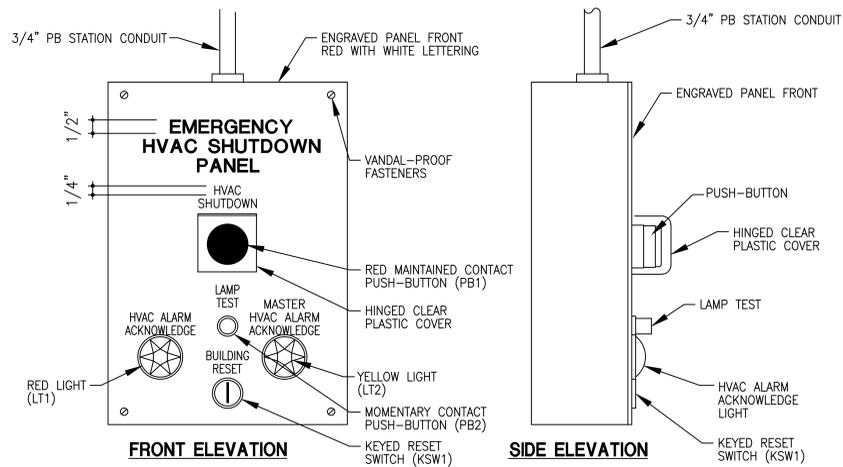

1 HVAC SHUTDOWN PANEL
M504 NTS (LOCATE IN LCPO/LPO ROOM 003)

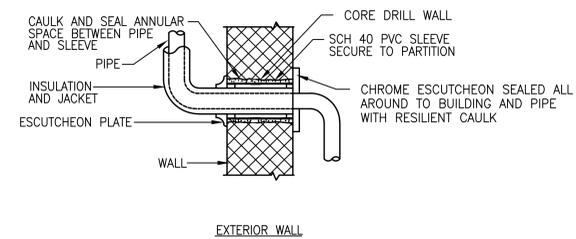

4 PIPE PENETRATION THRU WALLS
M504 NTS

FINAL SUBMISSION
APRIL 18, 2012

IF SHEET IS LESS THAN (30"x42") IT IS
A REDUCED PRINT; SCALE ACCORDINGLY

M504



 376 MIDDLE ST., FARMHSE. AL 36532 251-890-5778 ARCH. & ENGR. SEAL	NATURAL RESOURCES & ENVIRONMENTAL AFFAIRS SATISFACTORY TO DATE	P.W. DWG. NO.	DEPARTMENT OF THE NAVY NAVAL FACILITIES ENGINEERING COMMAND NAVAL SUPPORT ACTIVITY PANAMA CITY, FLORIDA
	SAFETY DEPARTMENT SATISFACTORY TO DATE	DRAWN BY R. LONDONO CHECKED BY R. DeLOACH SUPERVISOR B. COFFMAN	PANAMA CITY JOINT OUTPATIENT CLINIC NAVAL GULF COAST HEALTH CARE MECHANICAL DETAILS
FIRE DEPARTMENT SATISFACTORY TO DATE	APPROVED _____ DATE _____	SIZE F	CODE IDENT. NO. N/A
PUBLIC WORKS SUPERVISOR SATISFACTORY TO DATE	PUBLIC WORKS OFFICER	HQMC PROJ. NO. SCALE	CONSTR. CONTR. NO. T.O.# _____ SHEET 11 OF 12