


ABBREVIATIONS

| | | | | | |
|--------|---|--------|---|-----------|------------------------------------|
| & | AND | FFE | FINISHED FLOOR ELEVATION | OPP | OPPOSITE |
| @ | ANGLE | FF&E | FIXTURES, FURNITURE, & EQUIPMENT | OD | OUTSIDE DIAMETER |
| L | CENTERLINE, CLASS, CLOSE CHANNEL | FA | FIRE ALARM | OH | OVERHEAD, OVERHANG |
| CL | ANGLE | FIN GR | FINISH GRADE | PRKG | PARKING |
| C | CHANNEL | FE | FIRE EXTINGUISHER | PVMT | PAVEMENT |
| AFF | ABOVE FINISH FLOOR | FEB | FIRE EXTINGUISHER BRACKET | PLAM | PLASTIC LAMINATE |
| ACT | ACOUSTICAL TILE | FEC | FIRE EXTINGUISHER CABINET | PL | PROPERTY LINE |
| ADJ | ADJACENT | FP | FIREPROOF | PLYWD | PLYWOOD |
| A/C | AIR CONDITIONING | FLR | FLOOR | PVC | POLYVINYL CHLORIDE |
| ALT | ALTERNATE | FD | FLOOR DRAIN | PCF | POUNDS PER CUBIC FOOT |
| ALUM | ALUMINUM | FTG | FOOTING | PSF | POUNDS PER SQUARE FOOT |
| ARCH | ARCHITECT(URAL) | FDTN | FOUNDATION | PSI | POUNDS PER SQUARE INCH |
| AUTO | AUTOMATIC | GA | GAGE | PCC | PRECAST CONCRETE |
| BRG | BEARING | GALV | GALVANIZED IRON | PL | PLATE |
| BRG PL | BEARING PLATE | GC | GENERAL CONTRACTOR(OR) | P.T. | PRESSURE TREATED |
| BM | BEAM, BENCH MARK | GEJ | GUTTER EXPANSION JOINT | QT | QUARRY TILE |
| BLKG | BLOCKING | GL | GLASS, GLAZING | R | RADIUS, RISER, RANGE |
| BD | BOARD | GB | GRAB BAR | REF | REFERENCE, REFRIGERATOR |
| BOT | BOTTOM | GR LN | GRADE LINE | REG | REGISTER |
| BLDG | BUILDING | GF/GI | GOVERNMENT FURNISHED/GOVERNMENT INSTALLED | REINF | REINFORCE(D), (ING) |
| BUR | BUILT-UP ROOFING | GF/CI | GOVERNMENT FURNISHED/CONTRACTOR INSTALLED | REINFCING | REINFORCING BARS |
| CAB | CABINET | GMS | GALVANIZED METAL STUD | RCP | REFLECTED CEILING PLAN |
| CPT | CARPET(ED) | GYP BD | GYPSPUM BOARD | RET | RETURN |
| CI | CAST IRON | HDBD | HARDBOARD | RA | RETURN AIR |
| CB | CATCH BASIN | HDW | HARDWARE | REV | REVISION(S), REVISED |
| CF/CI | CONTRACTOR FURNISHED/CONTRACTOR INSTALLED | HTG | HEATING | RH | RIGHT HAND |
| CF/GI | CONTRACTOR FURNISHED/GOVERNMENT INSTALLED | HVAC | HEATING/VENTILATING/AIR | ROW | RIGHT OF WAY |
| CK | CAULK(ING) | HT | HEIGHT | RD | ROOF DRAIN |
| CLG | CEILING | HC | HOLLOW CORE, HANDICAP(PED) | RFG | ROOFING |
| CEM | CEMENT | HM | HOLLOW METAL | RM | ROOM |
| CID | COMPREHENSIVE INTERIOR DESIGN PACKAGE | HORIZ | HORIZONTAL | SCHED | SCHEDULE |
| CC | CONTRACTOR FURNISHED & INSTALLED | HB | HOSE BIBB | SECT | SECTION |
| CLR | CLEAR(ANCE) | HS | HOT STACK | SF | SQUARE FOOT/FEET |
| COL | COLUMN | INCL | INCLUDE(D), (ING) | SS | SERVICE SINK |
| CONC | CONCRETE | ID | INSIDE DIAMETER | SHT | SHEET |
| CON | CONTRACTING OFFICER'S REPRESENTATIVE | INV EL | INVERT ELEVATION | SIM | SIMILAR |
| CMU | CONCRETE MASONRY UNIT | INSUL | INSULATE(D), (ING), (ION) | SC | SOLID CORE |
| COND | CONDITION | INT | INTERIOR | S | SOUTH |
| CONSTR | CONSTRUCTION | INT | INTERIOR | SPKR | SPEAKER |
| CONT | CONTINUOUS OR CONTINUE | INV | INVERT | SPEC | SPECIFICATION(S) |
| CONTR | CONTRACT(OR) | JT | JOINT | SQ | SQUARE |
| CJ | CONSTRUCTION/CONTROL JOINT | KIT | KITCHEN | STD | STANDARD |
| CORR | CORRIDOR | LAM | LAMINATE(D) | STA | STATION |
| COTR | CONTRACTING OFFICER TECHNICAL REP | LAV | LAVATORY | STG | STORAGE |
| CU FT | CUBIC FOOT | L | LENGTH | STL | STEEL |
| CU YD | CUBIC YARD | LH | LEFT HAND | STOR | STORAGE |
| CW | CURTAIN WALL | LP | LAMPPOLE | SD | STORM DRAIN |
| DIA | DIAMETER | MH | MANHOLE | STRUCT | STRUCTURAL |
| DET | DETAIL | MFR | MANUFACTURER | SUSP | SUSPENDED |
| DIM | DIMENSION | MAX | MAXIMUM | SYMM | SYMMETRY(ICAL) |
| DIV | DIVISION | MECH | MECHANIC(AL) | SYS | SYSTEM |
| DS | DOWNSPOUT | MTL | METAL | TE | TOP ELEVATION |
| DL | DRAIN LEADER | M | METER(S) | TEL | TELEPHONE |
| DWG | DRAWING | MM | MILLIMETER(S) | TOC | TOP OF CONCRETE |
| DF | DRINKING FOUNTAIN | MIN | MINIMUM | TOP | TOP OF PAVING |
| DW | DISHWASHER | MISC | MISCELLANEOUS | TV | TELEVISION |
| EF | EACH FACE | MT | MOUNT | THK | THICKNESS |
| E | EAST | MTD | MOUNTED | T&B | TOP AND BOTTOM |
| ELEC | ELECTRIC(AL) | MTG | MOUNTING | T&G | TONGUE AND GROOVE |
| EWC | ELECTRIC WATER COOLER | MULL | MULLION | TOS | TOP OF SLAB, TOP OF STEEL |
| EL | ELEVATION | NAT | NATURAL | TYP | TYPICAL |
| ELEV | ELEVATOR | NOM | NOMINAL | UNO | UNLESS NOTED OTHERWISE |
| EQ | EQUAL | N | NORTH | VA | VA FURNISHED AND INSTALLED |
| EQUIP | EQUIPMENT | NIC | NOT IN CONTRACT | VA | VA FURNISHED, CONTRACTOR INSTALLED |
| EXH | EXHAUST | NTS | NOT TO SCALE | VERT | VERTICAL |
| EXIST | EXISTING | OC | ON CENTER(S) | VCT | VINYL COMPOSITION TILE |
| EXT | EXTERIOR | OF/OI | OWNER FURNISH/OWNER INSTALLED | WSCT | WAINSCOT |
| | | OF/CI | OWNER FURNISH/CONTRACTOR INSTALLED | WC | WATER CLOSET |
| | | OPNG | OPENING | WH | WATER HEATER |
| | | | | WP | WATERPROOFING |
| | | | | WWF | WELDED WIRE FABRIC |
| | | | | W | WEST, WIDTH, WIDE |
| | | | | W | WITH |
| | | | | W/O | WITHOUT |
| | | | | WD | WOOD |
| | | | | WB | WOOD BASE |


ROOM NAME ABBREVIATIONS

| | |
|----------|---|
| ADMIN. | ADMINISTRATIVE |
| AFGE | AMERICAN FEDERATION OF GOVERNMENT EMPLOYEES |
| COLL. | COLLECTION |
| COMM. | COMMUNICATIONS |
| CONF. | CONFERENCE |
| CORR. | CORRIDOR |
| CT | CART |
| DRESS. | DRESSING ROOM |
| EKG | ECCARDIOGRAM |
| EMS | ENVIRONMENTAL MANAGEMENT |
| | SULPLIES |
| EQUIP. | EQUIPMENT |
| FAM. TLT | FAMILY TOILET |
| GEN. | GENERAL |
| GYN. | GYNOCOLOGY |
| HAC | HOUSEKEEPING AIDES CLOSET |
| HAZ. | HAZARDOUS |
| INFECT. | INFECTIOUS |
| INST. | INSTRUMENT |
| KIT. | KITCHEN |
| MECH. | MECHANICAL |
| MED. | MEDICAL/MEDICINE |
| MGR. | MANAGER |
| MP | MULTIPURPOSE |
| OFF. | OFFICE |
| OP. | OPERATORY |
| OPER. | OPERATIONS |
| PT. TLT | PATIENT TOILET |
| PROS. | PROSTHETIC |
| RECEP. | RECEPTION |
| RM. | ROOM |
| R.O.I. | RELEASE OF INFORMATION |
| | OFFICE |
| RR | RESTROOM |
| SECT. | SECRETARY |
| SERV. | SERVICE |
| ST. TLT | STAFF TOILET |
| STER. | STERILIZED |
| STOR. | STORAGE |
| STG. | STORAGE |
| SUPP. | SUPPLY |
| TECH. | TECHNICIAN |
| TLT. | TOILET |
| UTIL. | UTILITY |
| VOL. | VOLUNTEER |
| WKST. | WORKSTATION |

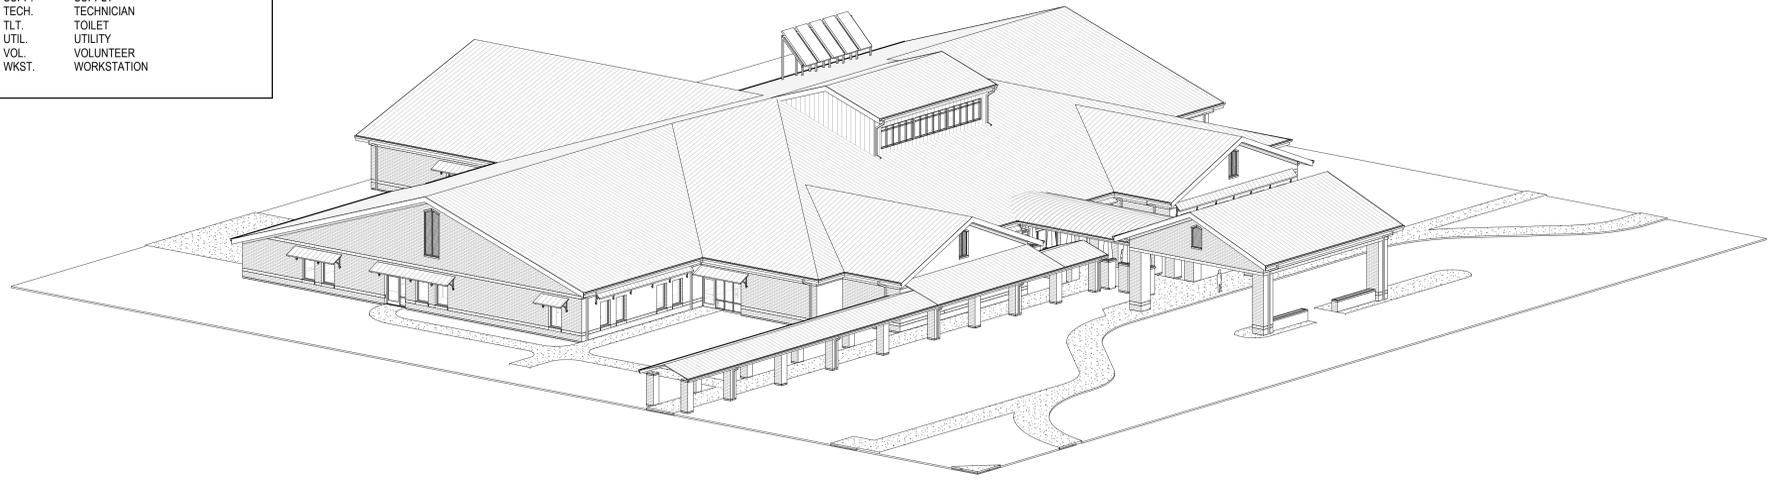

(CHARACTER IMAGE ONLY)
 1 3D BIRD'S EYE VIEW FROM SOUTHWEST
 AS100

SYMBOLS LEGEND

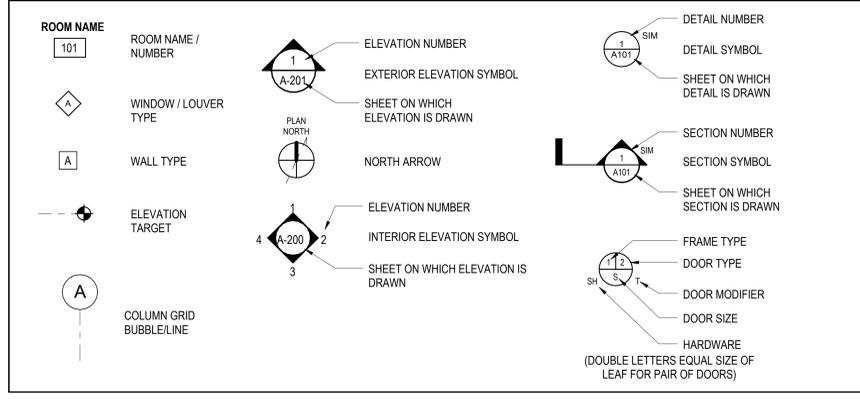

CONSULTANTS:

| | | |
|--|--|---|
| CNL: KENNETH HORNE & ASSOCIATES 7201 NORTH 9TH AVENUE, STE. 6 PENSACOLA, FLORIDA 32504 PH: (850) 471-8005 FX: (850) 471-8003 | COMANDR: SCHMIDT CONSULTING GROUP, INC. 139 EAST GOVERNMENT STREET PENSACOLA, FLORIDA 32502 PH: (850) 438-0050 FX: (850) 432-8611 | SURVEYORS: KCI TECHNOLOGIES, INC. 10401 HIGHLAND MANOR DRIVE, SUITE 120 TAMPA, FLORIDA 33618 PH: (813) 740-2300 |
| LANDSCAPE ARCHITECT: C&S GROUP, INC. 6300 PICCADILLY SQUARE DRIVE MOBILE, ALABAMA 36689 PH: (251) 344-4023 FX: (251) 344-4052 | ARCHITECTURE: BULLOCK TICE ASSOCIATES, INC. 909 EAST CERVANTES STREET PENSACOLA, FL 32501 PH: (850) 434-5444 FX: (850) 432-6208 | |

ARCHITECT/ENGINEERS:

BES DESIGN/BUILD, LLC
 766 Middle St, Fairhope, AL 36532
 Phone: 251.990.5778 Fax: 251.990.3716

| | | |
|---|---|----------------------------------|
| Drawing Title ABBREVIATIONS AND LEGENDS | Project Title PANAMA CITY JOINT OUTPATIENT CLINIC VA GULF COAST HEALTH CARE | Project Number 520-326 |
| Approved: Project Director | Location PANAMA CITY, FLORIDA | Building Number - |
| | Date MARCH 2012 | Drawing Number AS100 |
| | Checked BM | Drawn TW/MF |
| | | Dwg. 1 of 42 |

FINAL SUBMISSION

Office of Construction and Facilities Management
 Department of Veterans Affairs