



12
8
4
0
SCALE: 3/4" = 1'-0"

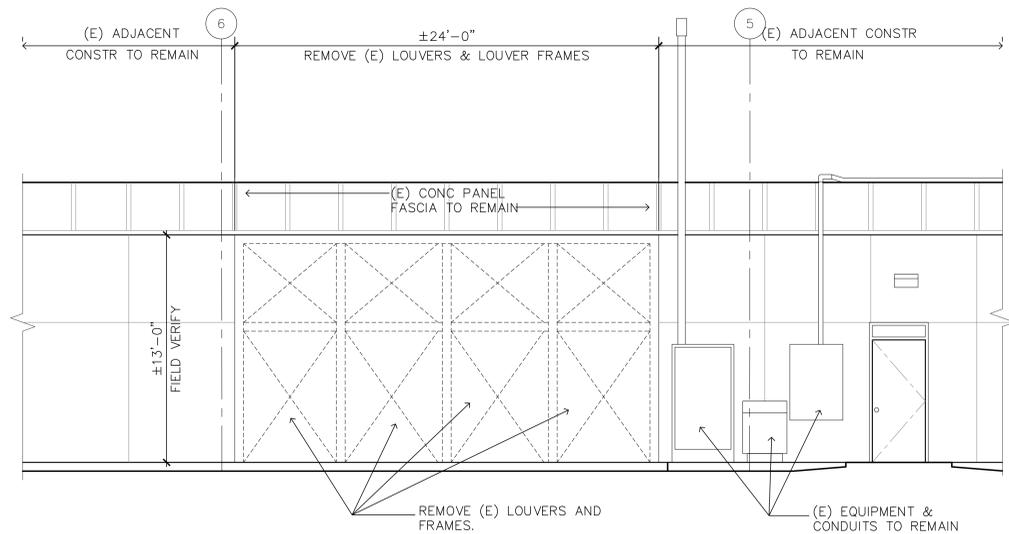


1 NORTH ELEVATION DEMOLITION
SCALE: 1/4" = 1'-0"

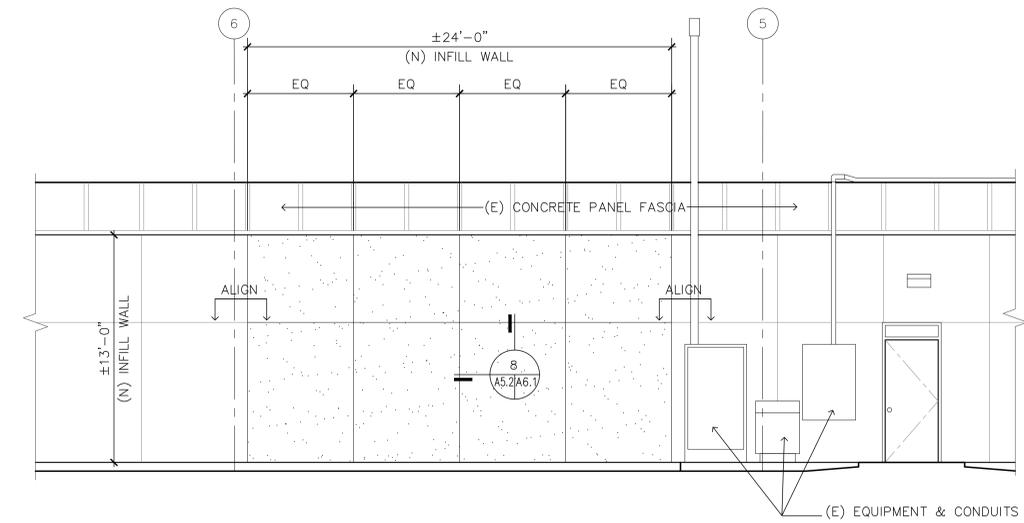


2 NEW NORTH ELEVATION
SCALE: 1/4" = 1'-0"

12
8
4
0
SCALE: 1/2" = 1'-0"

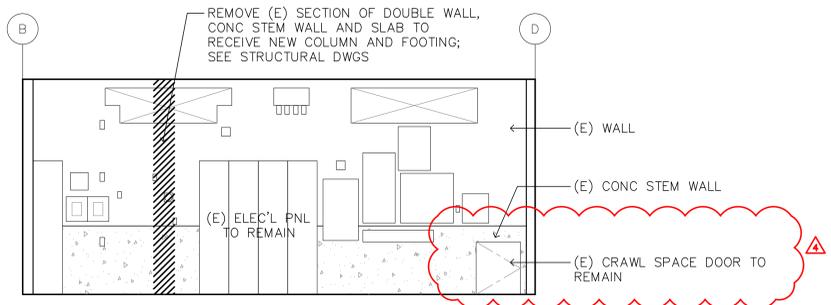

3 (E) EAST WALL @ MECH RM 1D645
SCALE: 1/4" = 1'-0"


- NOTE:**
- REFER TO STRUCTURAL, ELECTRICAL AND MECHANICAL PLANS FOR MORE DEMOLITION PLANS AND NOTES.
 - COORDINATE W/ COTR ON RELOCATION OF FIRE ALARM DEVICES AND CONDUITS.

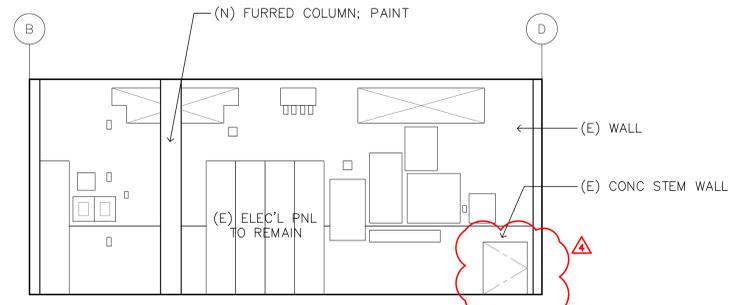

4 (N) EAST WALL @ MECH RM 1D645
SCALE: 1/4" = 1'-0"


- NOTE:**
- REFER TO STRUCTURAL, ELECTRICAL AND MECHANICAL PLANS FOR MORE INFORMATION.
 - COORDINATE W/ COTR ON RELOCATION OF FIRE ALARM DEVICES AND CONDUITS.

12
8
4
0
SCALE: 1/4" = 1'-0"

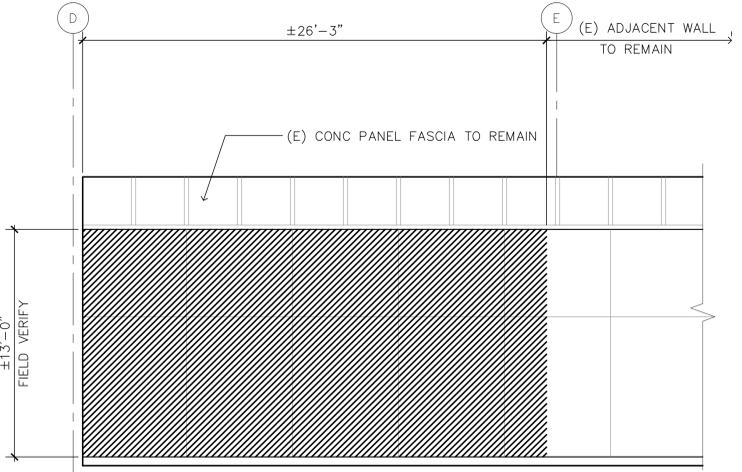

5 (E) EAST WALL @ COURTYARD
SCALE: 1/4" = 1'-0"


- NOTE:**
- REFER TO STRUCTURAL PLANS FOR MORE DEMOLITION PLANS AND NOTES.

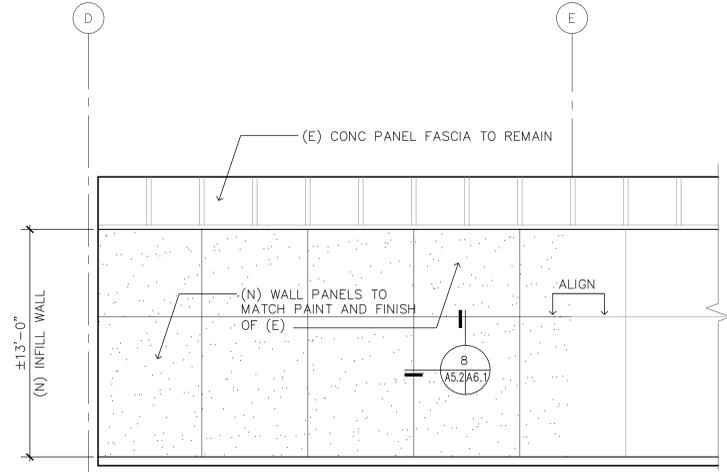

6 (N) EAST WALL @ COURTYARD
SCALE: 1/4" = 1'-0"

- NOTE:**
- SEE WALL SECTION: 1 (A5.1A6.1)

12
8
4
0
SCALE: 1/8" = 1'-0"

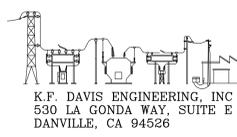

Revisions: △ DATED 11/10/08 △ DATED 11/19/08 △ DATED 07/14/09 ▲ DATED 12/05/2011	Drawing Title: BUILDING AND INTERIOR ELEVATIONS	Project Title: BLDG 650 REPLACE AIR HANDLERS 1 THRU 4, 7 AND 9 - 15	Date: 12/05/11
Approved:	Approved: Medical Center Director	Drawn: VMAN	Project No.: 61244-07-342
Approved:	Approved: Chief, Engineering Service	Checked: JA	Building Number: A5.2
		Location: MATHER VAMC MATHER CALIFORNIA	Draw. Of

