


GENERAL NOTES:

- INTERIOR DIMENSIONS GIVEN ARE FROM FINISH TO FINISH OR TO CENTERLINE OF COLUMN UNLESS NOTED OTHERWISE.
- TOLERANCES FOR BUILT-IN ITEMS, INCLUDING ARCHITECTURAL WINDOWS, CASEWORK AND APPLIANCES, MUST BE FIELD VERIFIED BY THE CONTRACTOR TO ENSURE ADEQUATE CLEARANCES AND PROPER FIT.
- REFER TO REFLECTED CEILING PLANS FOR CEILING HEIGHTS AND TYPES.
- REFER TO SPECIFICATIONS FOR FINISHES AND MANUFACTURERS.
- REFER TO 1/8" SCALE FLOOR PLANS FOR DOOR DESIGNATIONS AND 1/4" SCALE EXTERIOR ELEVATIONS FOR WINDOW DESIGNATIONS.
- REFER TO A700 SERIES FOR TYPICAL MOUNTING HEIGHTS OF ACCESSORIES AND DEVICES. PROVIDE FIRE RETARDANT WOOD BLOCKING FOR ACCESSORIES AND DEVICES. SEE DETAIL 19/A702 FOR GRAB BAR AND CABINETRY METAL BLOCKING.
- ALL DISPENSERS, INCLUDING SHARPS, PAPER TOWEL, SOAP, HAND SANITIZER AND GLOVE DISPENSERS ARE FURNISHED BY THE GOVERNMENT & INSTALLED BY THE CONTRACTOR.
- REFER TO LIFE SAFETY PLANS FOR LOCATION OF FIRE RATED PARTITIONS.
- PROVIDE FIBER-REINFORCED WATER & MOLD RESISTANT GYPSUM PANELS AT ALL WET WALL LOCATIONS AND WALLS BEHIND AND ADJACENT TO SINKS.
- CONFIRM ALL CABINET & COUNTER TOP LAYOUTS WITH SHOP DRAWINGS.
- REFER TO KITCHEN EQUIPMENT DRAWINGS FOR ALL APPLIANCE INFORMATION.

TOILET ACCESSORIES LEGEND:

- ITEMS PURCHASED AND INSTALLED BY CONTRACTOR:**
- SWING UP GRAB BARS W/ INTEGRATED TOILET PAPER DISPENSER
 - SHOWER GRAB BAR
 - TOWEL BAR
 - SHOWER TRANSFER SEAT
 - ROBE HOOK
 - RECESSED MEDICINE CABINET - REFER TO SPECIFICATIONS
- ITEMS PURCHASED BY GOVERNMENT AND INSTALLED BY CONTRACTOR:**
- TOILET PAPER DISPENSERS
 - SIDE BY SIDE DOUBLE ROLL BATHROOM DISPENSER (#56784) BY GEORGIA PACIFIC
 - PAPER TOWEL HOLDERS
 - SOFT PULL TRANSLUCENT SMOKE DISPENSER (CENTER PULL) (#58204) (SIZE: 11.5" x 9.25" x 8.75") FOR ROLLS
 - SOAP DISPENSER
 - BACI-FOAM SOAP DISPENSER (#92723188) FOR BACI-FOAM SOAP (#E61806-999) BY ECOLAB
- ITEMS PURCHASED AND INSTALLED BY GOVERNMENT:**
- HAND SANITIZER DISPENSER
 - SHARPS CONTAINER
 - WASTE BASKET
 - GLOVES DISPENSER

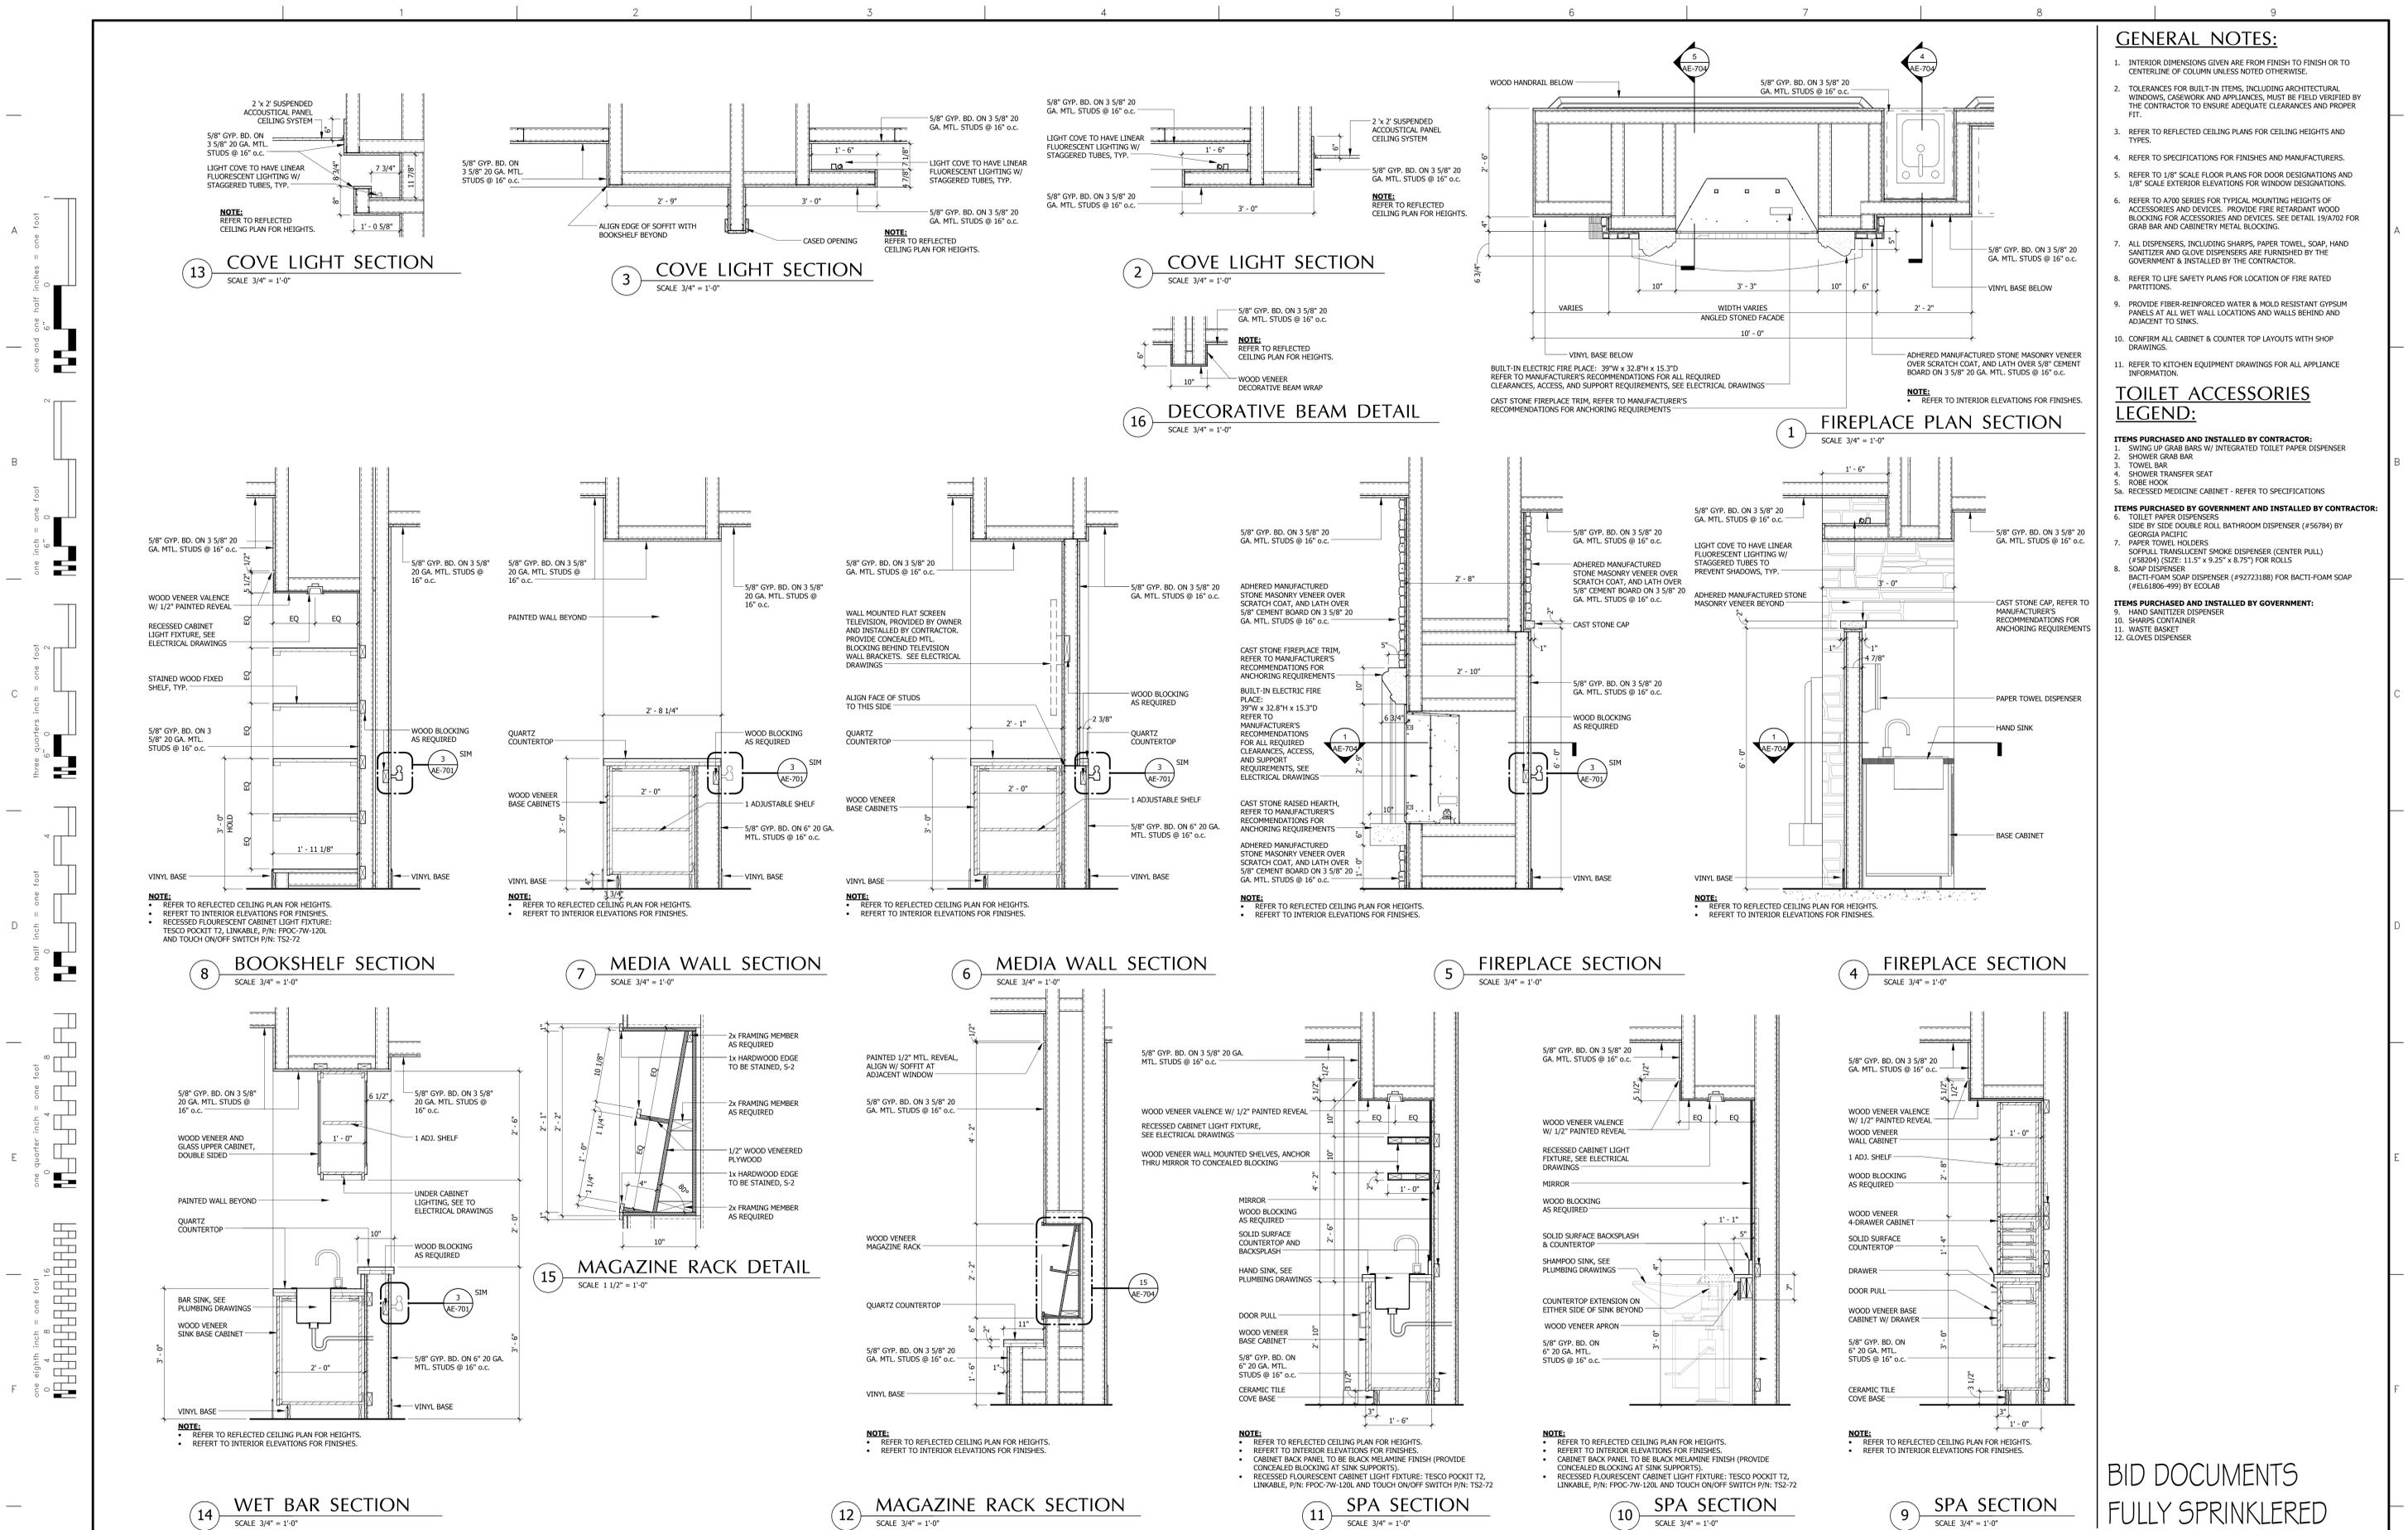

BID DOCUMENTS FULLY SPRINKLERED

CONSULTANTS:

ARCHITECT/ENGINEERS:



C.C. HODGSON ARCHITECTURAL GROUP

Drawing Title
INTERIOR DETAILS

Approved: Project Director

Project Title
RELOCATE DEMENTIA UNIT

Building Number
513

Location
VAMC MARTINSBURG

Date: _____
Checked: _____
Author: _____

Project Number
VA PN 613-107

Building Number
513

Drawing Number
AE-704

Dwg. of: --

Office of Construction and Facilities Management

