


one and one half inches = one foot
 one inch = one foot
 three quarters inch = one foot
 one half inch = one foot
 one quarter inch = one foot
 one eighth inch = one foot

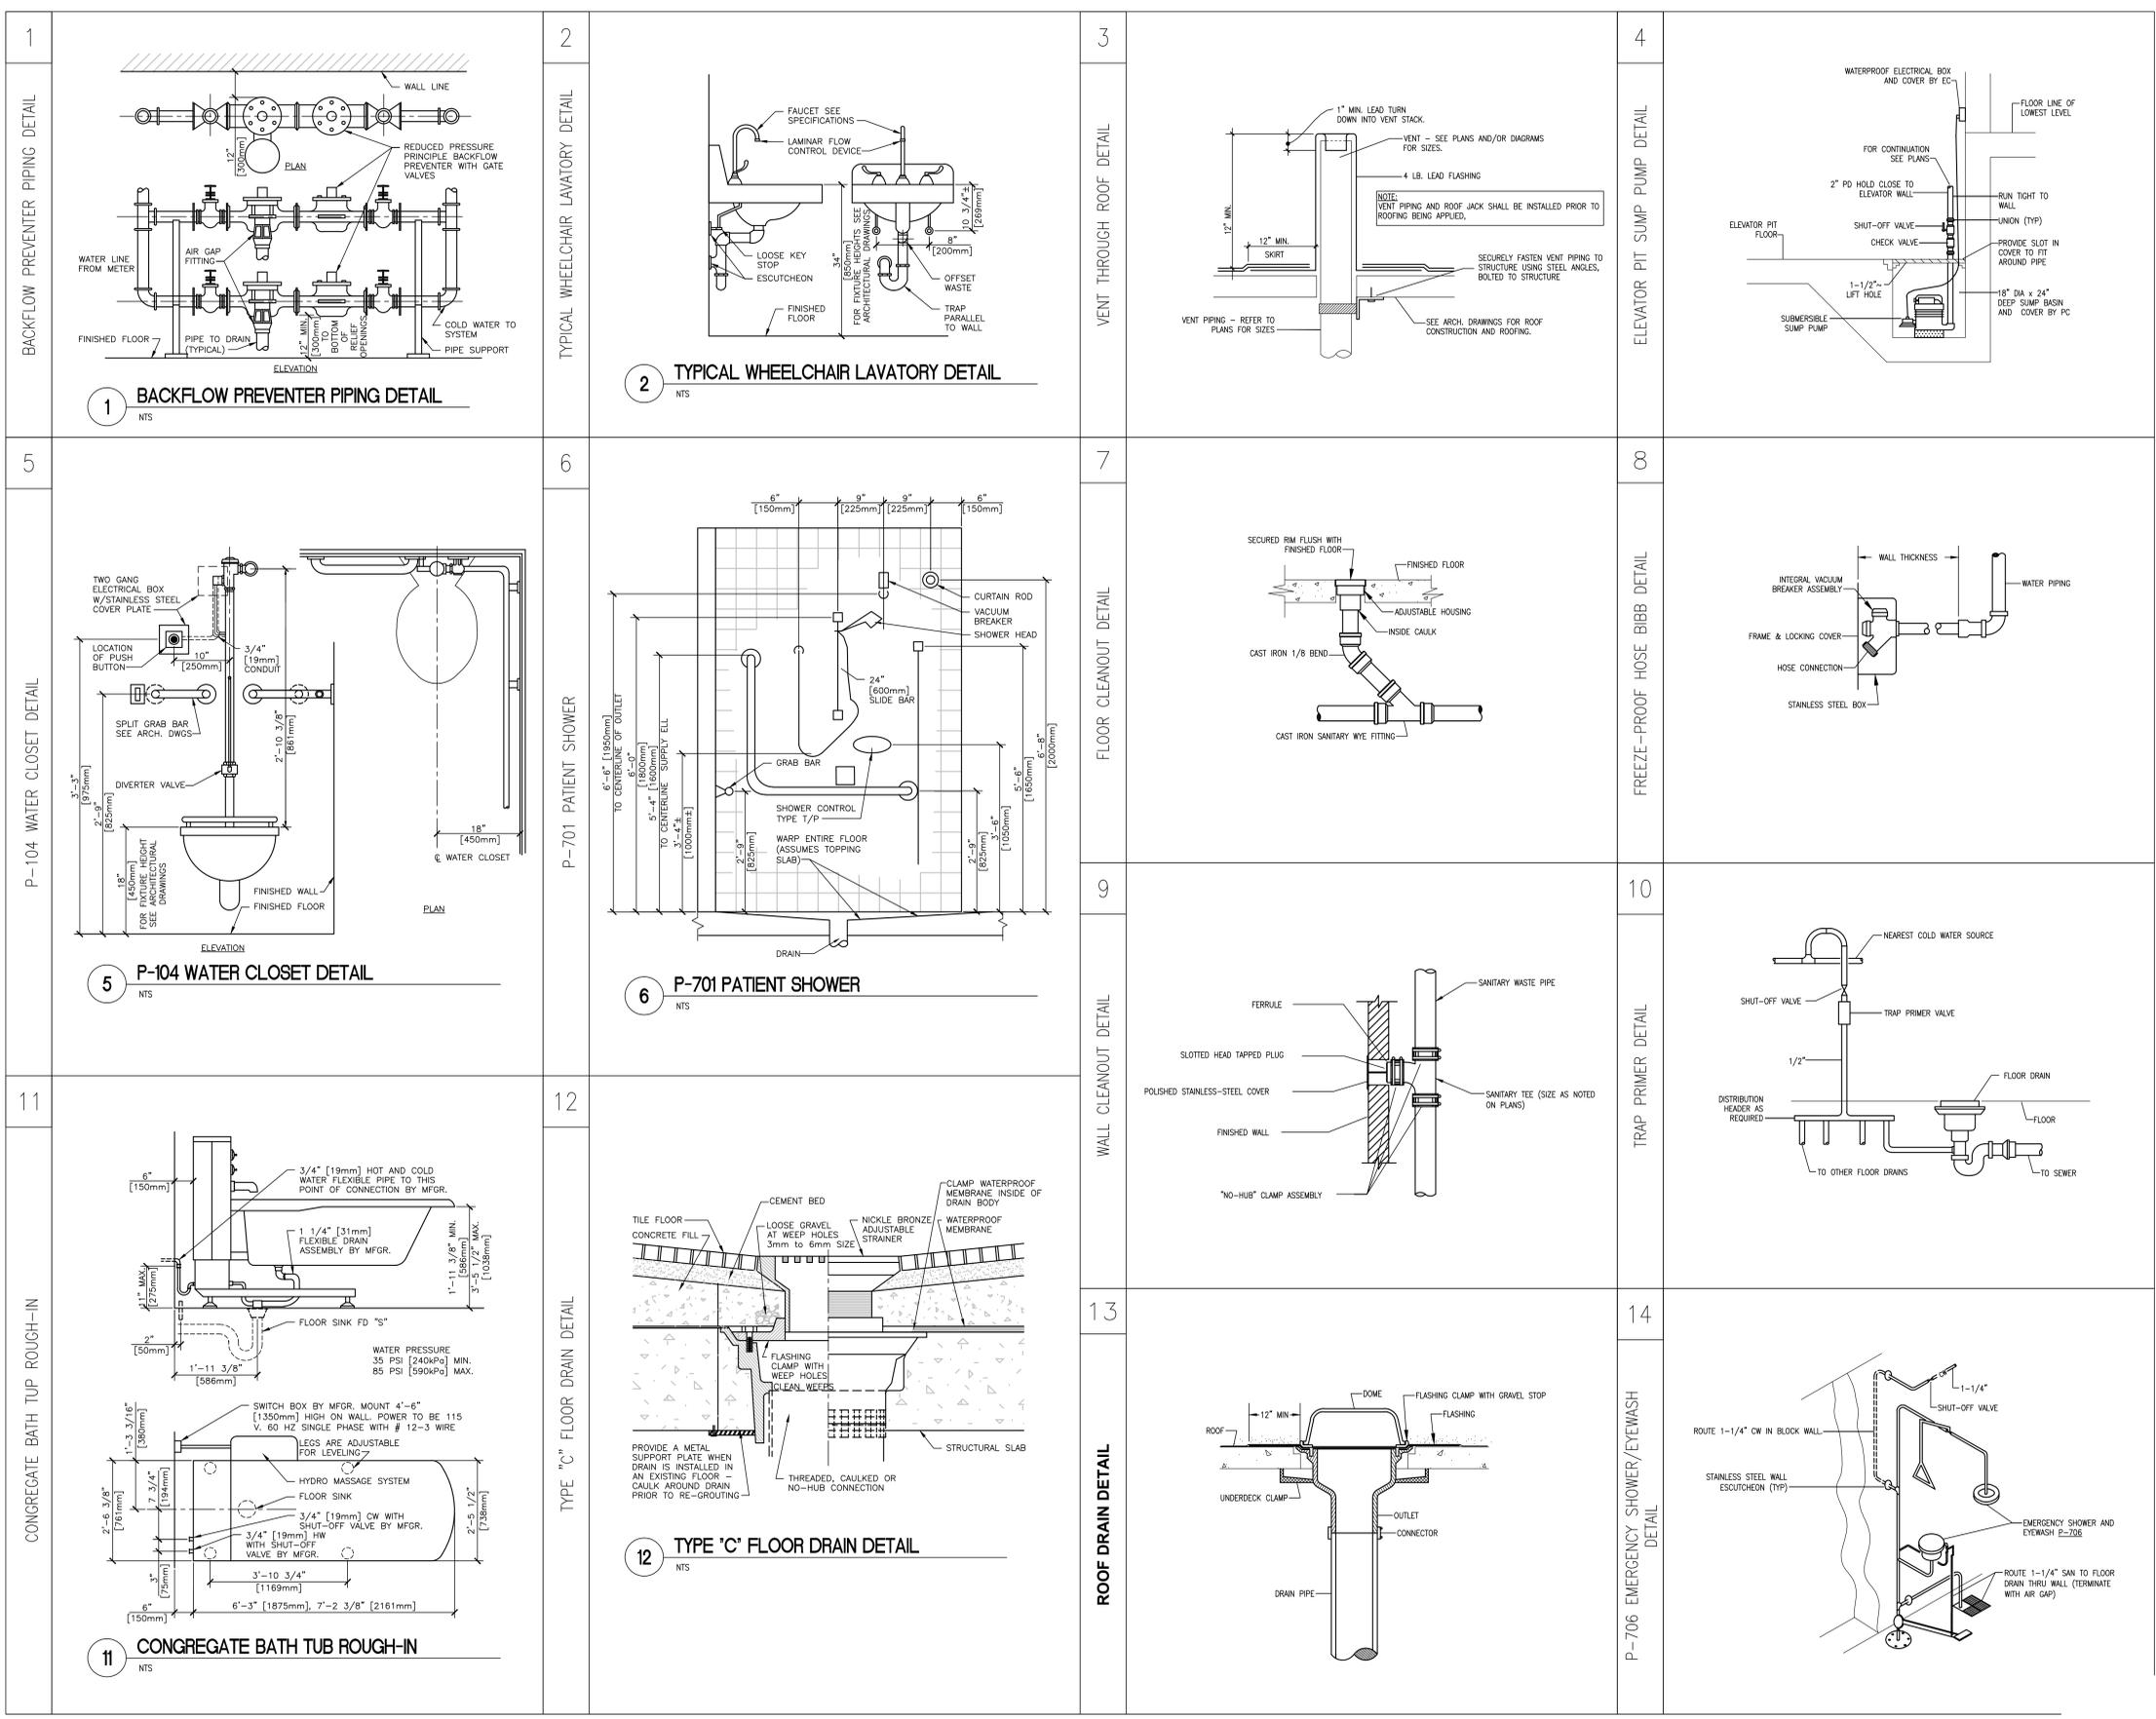

BID DOCUMENTS
 FULLY SPRINKLERED

ARCHITECT: C.C. HODGSON ARCHITECTURAL GROUP PC		ENGINEERS: Westlake Reed Leskosky 1634 EYE ST, NW, STE 900 WASHINGTON, DC 20006	Drawing Title PLUMBING DETAILS		Project Title RELOCATE DEMENTIA UNIT		Project Number VA FM 613-207		Office of Construction and Facilities Management
			Approved: Project Director		Location VAMC MARTINSBURG		Building Number 513		
Revisions:	Date				Date 08/06/2012	Checked SCS	Drawn C/JW	Drawing Number P-501	Dwg. of -