



- POWER GENERAL NOTES**
- UNLESS NOTED OTHERWISE BY FULL PANEL NAME: CIRCUIT ALL FIXTURES, DEVICES, AND EQUIPMENT ON THIS FLOOR TO PANELS IN THE EAST AND WEST ELECTRICAL CLOSETS AS INDICATED BY EACH DEVICE'S ANNOTATION. REFER TO ELECTRICAL SYMBOL LEGEND ON E-001 FOR CIRCUIT ANNOTATION CONVENTION.
 - FOR EACH MECHANICAL UNIT, PROVIDE CIRCUIT, ASSOCIATED DISCONNECT SWITCHES, DRIVES, CONTROLLERS, AND OTHER ITEMS AS SCHEDULED ON THE ELECTRICAL CONNECTION SCHEDULE. SEE SHEET E-602.
 - PANELBOARD ABBREVIATIONS ARE USED FOR CIRCUITING. REFER TO PANELBOARD HOMERUN ABBREVIATIONS BOXED NOTE ON THIS SHEET FOR DEFINITIONS.
 - PANELBOARD CIRCUIT TAGS ARE DRAWN NEXT TO DEVICE OR EQUIPMENT IN LIEU OF CONVENTIONAL CIRCUIT SEGMENTS.

| PANELBOARD HOMERUN ABBREVIATIONS | |
|----------------------------------|----------|
| HC1 | = 2EH-C1 |
| L1 | = 1NL1 |
| LC1 | = 2EL-C1 |
| 1KL1 | = 1KL1 |
| 2KL1 | = 2KL1 |
| MDP | = MDP |

- SHEET KEYED NOTES**
- ELECTRICAL EMERGENCY CIRCUIT FOR 513-AHU-1: 480V, 3 PH, 3W. CIRCUIT IS FOR SUPPLY FAN, EXHAUST FAN, HEAT WHEELS, AND CONTROLS. PROVIDE 3#8 + #10, 3/4"C. PROVIDE NEMA 3R, 3P-60A NON-FUSED DISCONNECT SWITCH.
 - CIRCUIT TO PANEL 2NL1.

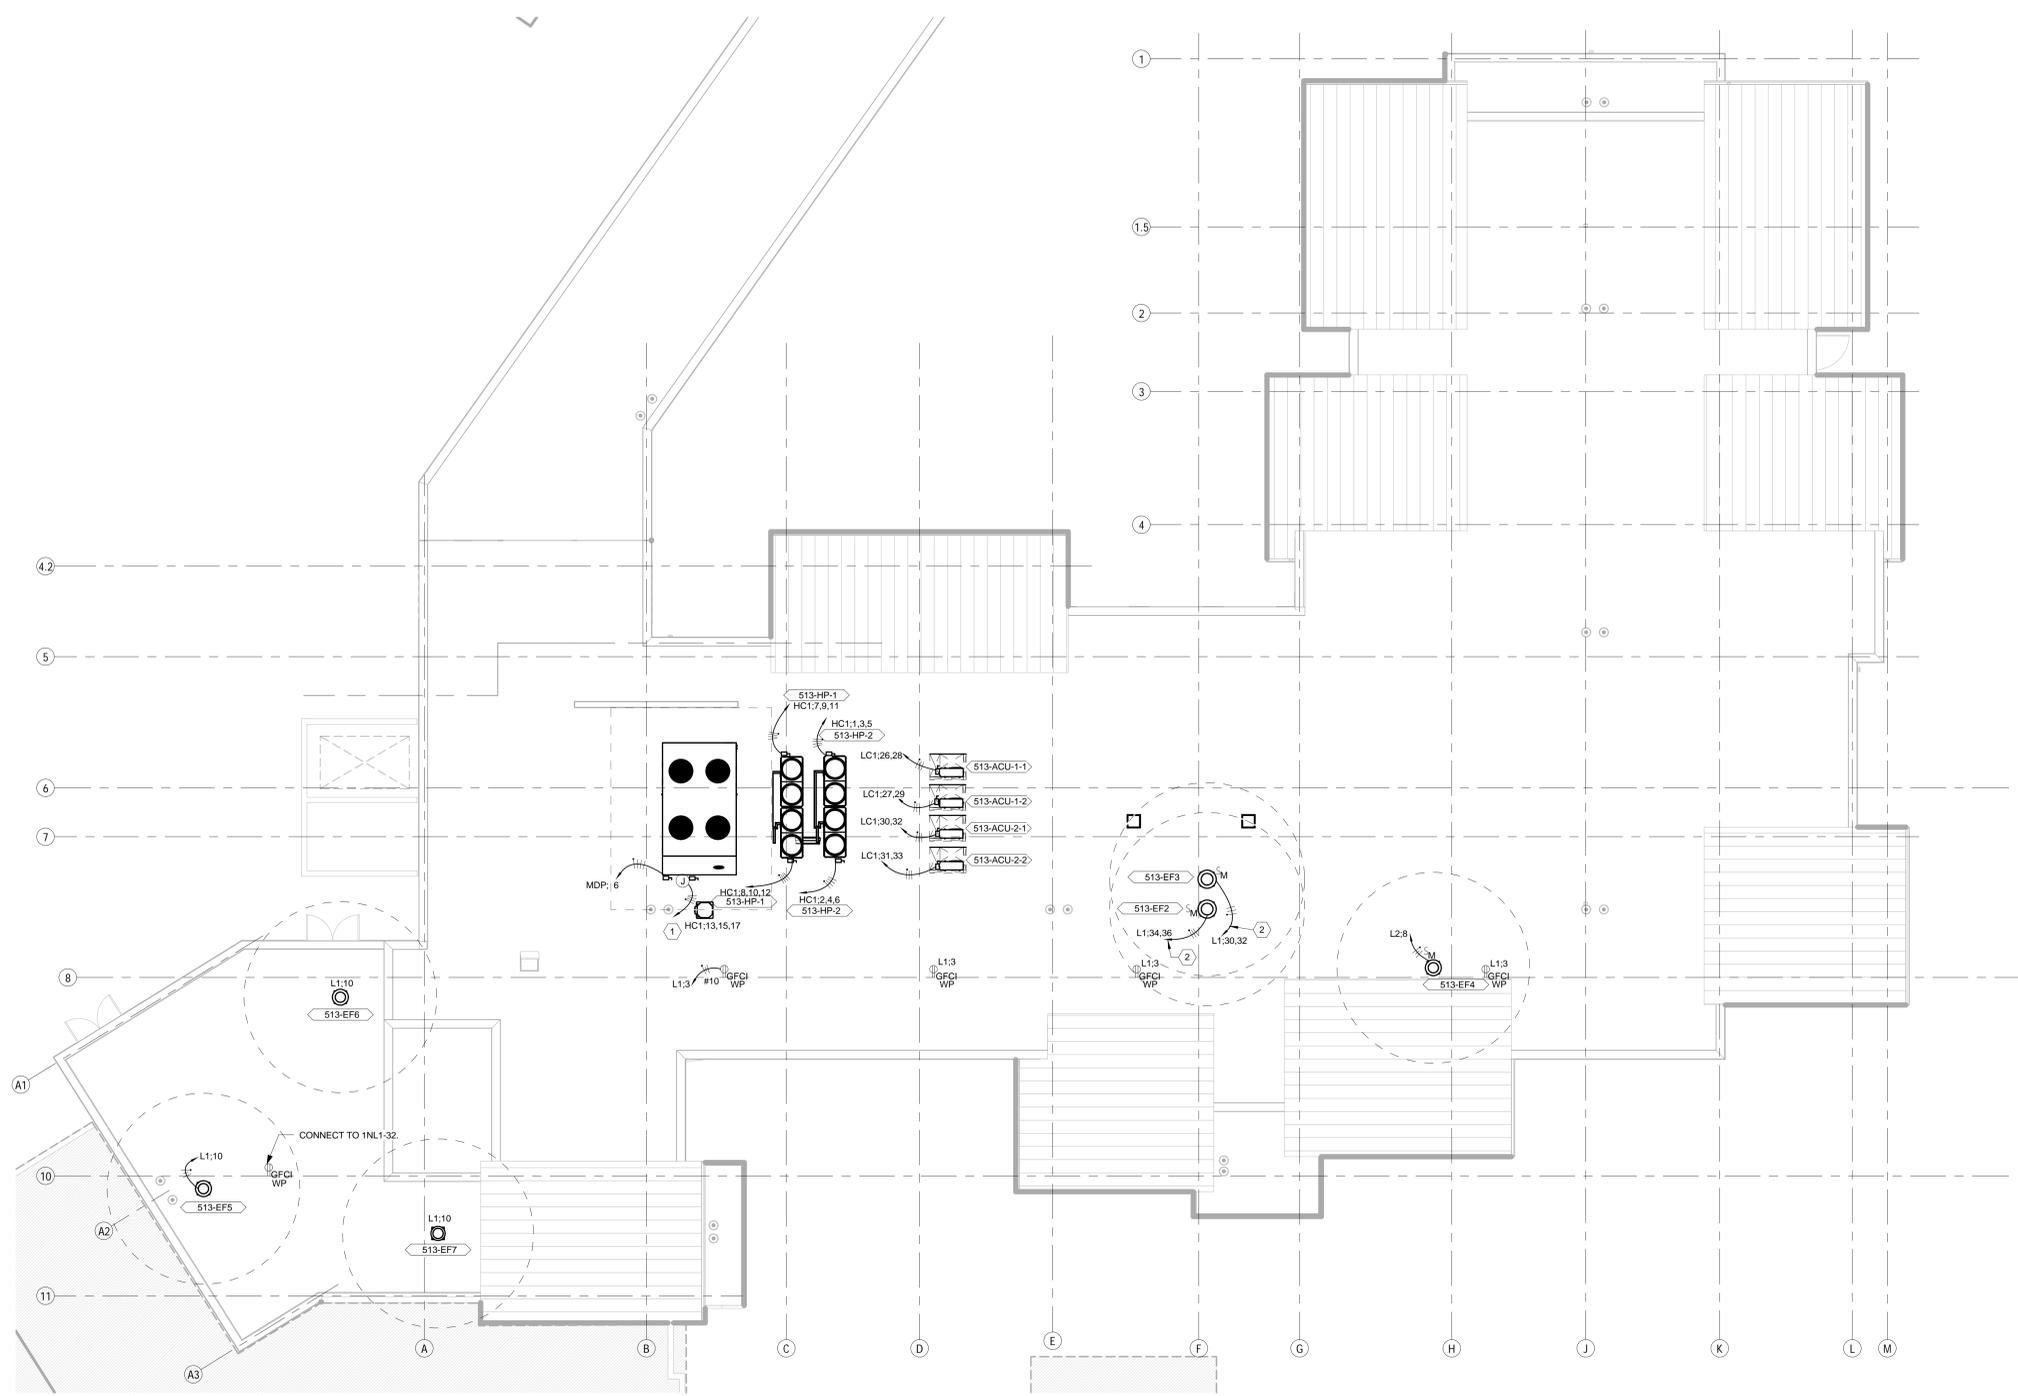

 1 ROOF POWER PLAN
1/8" = 1'-0"



BID DOCUMENTS
FULLY SPRINKLERED

| Revisions: | Date |
|------------|------|
| | |
| | |
| | |
| | |

ARCHITECT:
C.C. HODGSON
ARCHITECTURAL GROUP



ENGINEERS:
Westlake Reed Leskosky
1634 EYE ST, NW, STE 900
WASHINGTON, DC 20006

Drawing Title
ELECTRICAL NEW WORK ROOF POWER PLAN

Approved: Project Director

Project Title
RELOCATE DEMENTIA UNIT

Project Number
VA PN 613-207

Building Number
513

Location
VAMC MARTINSBURG

Date
08/06/2012

Checked
GSL

Drawn
DRW

Drawing Number
EP-104

Dwg. of --

Office of
Construction
and Facilities
Management

Department of
Veterans Affairs