


WSHP PACKAGE PLAN VIEW
SCALE: NTS

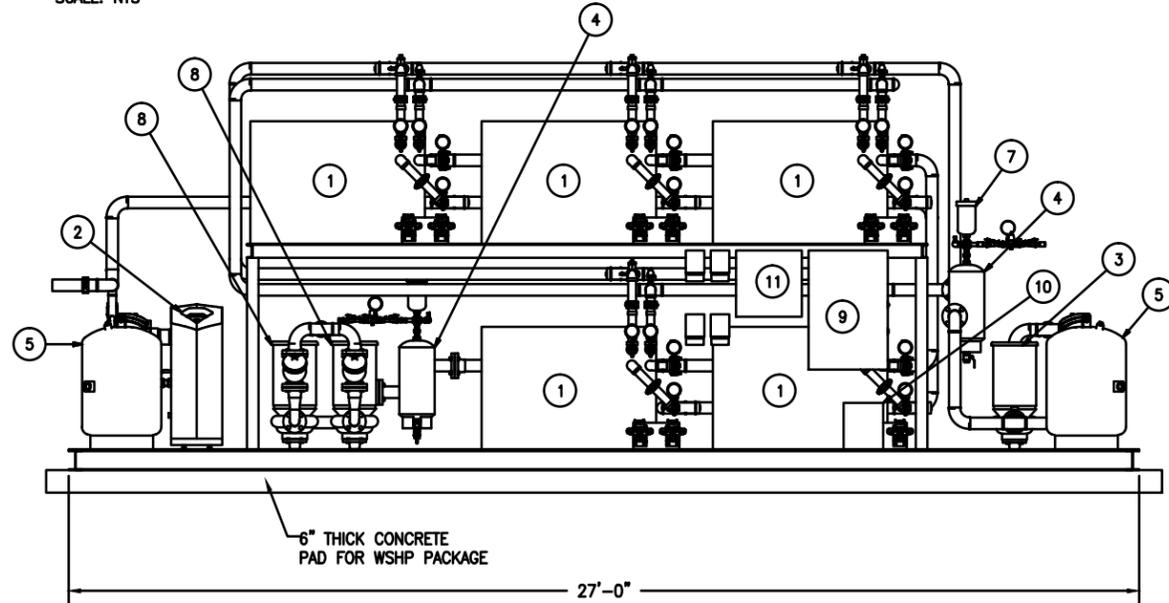


WSHP PACKAGE SIDE ELEVATION
SCALE: NTS

BASIS OF DESIGN. PROVIDE INDICATED EQUIPMENT OR EQUIPMENT OF EQUAL PERFORMANCE, CAPACITY AND QUALITY.

PARTS LIST		
ITEM	QTY	DESCRIPTION
1	5	CLIMATE MASTER TMW120 WSHP-REFER TO HEAT PUMP SCHEDULE CRITERIA
2	1	LOCHINVAR KBN 500 BOILER- REFER TO BOILER BOILER CRITERIA
3	4	B&G MODEL 80 -REFER TO PUMP SCHEDULE P-2 CRITERIA
4	3	B&G MODEL RL-3 AIR SEPARATOR
5	3	B&G SERIES B200 DIAPHRAGM TANK
6	2	NOT USED
7	3	B&G MODEL 107A AIR VENT
8	2	B&G SERIES REFER TO PUMP SCHEDULE P-3 CRITERIA
9	1	LOAD CENTER
10	1	TRANSFORMER
11	1	SPP LOAD CENTER
12	2	ALTIVAR 212 VFD, 7-1/2 HP, 3/60/480
13	10	B&G PL-35 CIRCULATING PUMPS REFER TO PUMP SCHEDULE P-6 THRU 15
14	2	B&G SERIES 80 BOILER PUMPS REFER TO PUMP SCHEDULE P-5

* BID ITEM 0002 ONLY

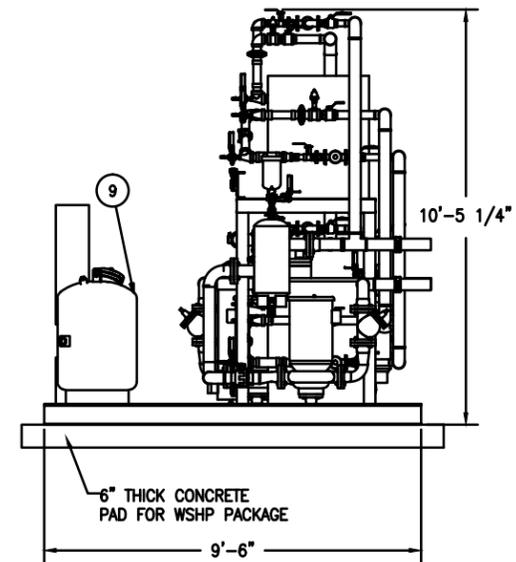

WSHP PACKAGE END ELEVATION
SCALE: NTS

Scale: AS SHOWN

ARCHITECT/ENGINEERS:	Drawing Title AMENDMENT #4 MH006-2	Project Title PANAMA CITY JOINT OUTPATIENT CLINIC VA GULF COAST HEALTH CARE	Project Number Building Number 	Office of Construction and Facilities Management Department of Veterans Affairs
	Approved: Project Director 	Location PANAMA CITY, FLORIDA	Drawing Number MH006-2 Dwg. of	