


**GENERAL NOTES:**


- REFER TO G-002 - G-006 LIFE SAFETY PLANS FOR OVERALL FLOOR PLANS REGARDING ELECTRICAL ROOM LOCATIONS.
- NEW & EXISTING CONDUIT SHOWN FOR VISUAL PURPOSES ONLY & DO NOT REFLECT ACTUAL OR FINAL LAYOUT.
- ALL MECHANICAL EQUIPMENT, PANELS, AND CONDUITS SHOWN ARE BASED ON SITE OBSERVATIONS AND EXISTING DOCUMENTS. CONTRACTOR SHALL VERIFY IN A NON-DESTRUCTIVE MANNER ALL EXISTING CONDITIONS PRIOR TO CONSTRUCTION.
- NOT ALL ITEMS ARE SHOWN ON THIS PLAN, INCLUDING CABLING AND CONDUITS. CONTRACTOR SHALL COORDINATE WITH ALL OTHER TRADES.
- ALL OUTAGES TO BE COORDINATED WITH VA COR AND APPROVED IN WRITING BY VA, MEDICAL CENTER.
- CONTRACTOR SHALL BE RESPONSIBLE FOR SCANNING ANY FLOOR OR ROOF PRIOR TO MAKING ANY DUCT, PIPE, OR CONDUIT PENETRATION. CONTRACTOR IS TO VERIFY THE PRESENCE OF EXISTING CONDUIT IN THE EXISTING SLAB PRIOR TO ANY WORK TAKING PLACE.
- CONNECT NEW & EXISTING FIRE/SMOKE DETECTION SYSTEMS TO EXISTING FIRE ALARM SYSTEM WHERE REQUIRED.

**PLAN NOTES:**


- — = EXISTING ELECTRICAL CONDUIT
- - - = DEMOLISH EXISTING ELECTRICAL CONDUIT
- 1 = INSTALL ELECTRICAL CONDUIT PIPE SUPPORTS PER DETAIL 14M-201. SPACE PER MANUFACTURER'S INSTRUCTIONS
- 2 = ANCHOR CONDUIT TO MASONRY WALL BEHIND REFRIGERANT LINES

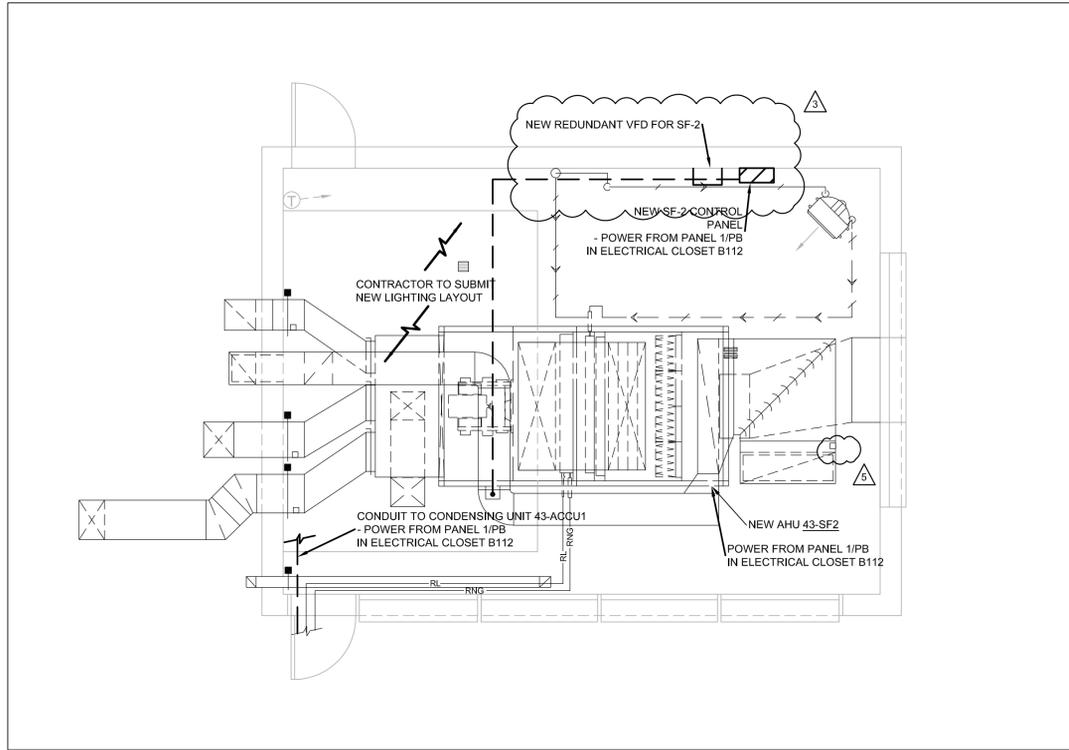

1 B-200 MECHANICAL ROOM FLOOR PLAN (SF-2 & 3)  
Scale: 1/4" = 1'0"  
NORTH

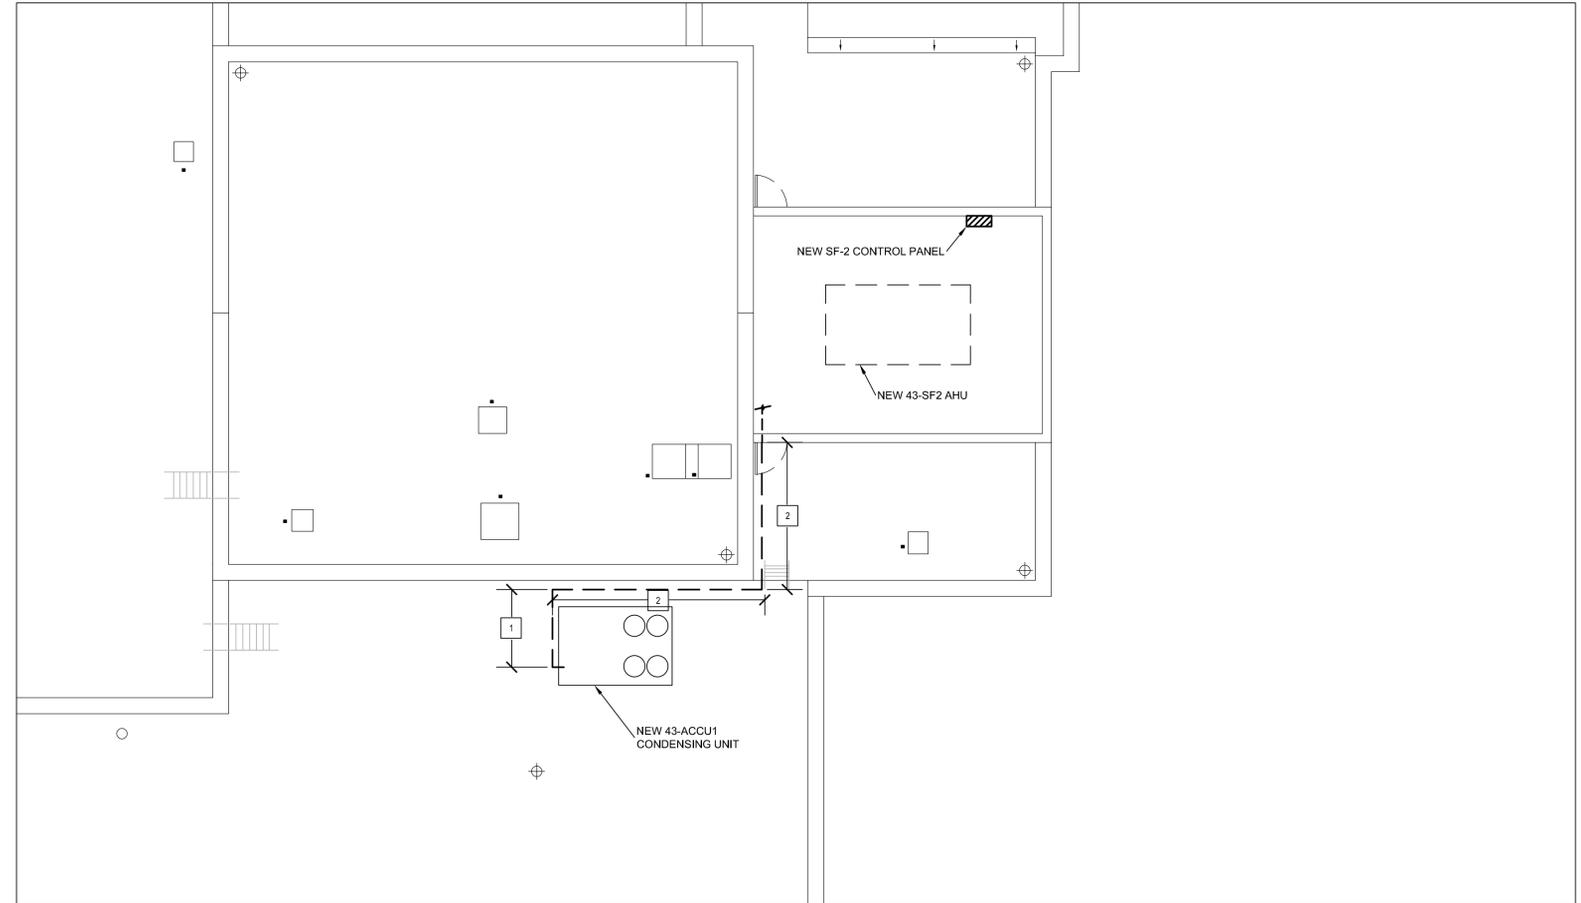

2 ROOF PLAN  
Scale: 1/4" = 1'0"  
NORTH

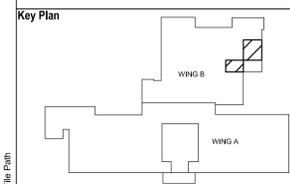

|           |   |            |                |
|-----------|---|------------|----------------|
| Revision: | 5 | ADDENDUM 5 | 12/05/19       |
|           | 3 | ADDENDUM 3 | Date: 11/27/19 |

Office of Construction and Facilities Management  
U.S. Department of Veterans Affairs

Drawing Title: SF-2 ELECTRICAL PROPOSED PLAN  
Approved: Project Director  
DLK

Phase: BID DOCUMENTS  
SPRINKLERED

Project Title: BLDG 43 SF1 & SF2 HVAC REPLACEMENT  
Location: BLDG 43 A & B WING PENTHOUSES  
Issue Date: 10/2/19  
Checked: MSO  
Drawn: ASB

Project Number: 695-19-137  
Building Number: 43  
Drawing Number: E-101