


LEGEND

- Glazing to remain
- Remove glazing, typ.
- Existing wall to remain
- New 2x2 light fixture, see electrical
- New 2x4 light fixture, see electrical
- New 1x4 light fixture, see electrical
- New pendant light, see electrical
- Nurse call station, see electrical
- New recessed can light, see electrical
- Air-curtain, See Mechanical
- New 2X2 acoustical ceiling grid and new acoustical ceiling tiles
- Existing acoustical ceiling grid to remain, replace acoustical ceiling tiles complete, typ.
- Existing return diffuser, see mechanical
- Existing supply diffuser, see mechanical
- Existing exhaust register, see mechanical
- New return diffuser, see mechanical
- New supply diffuser, see mechanical
- New exhaust register, see mechanical
- Existing exit sign to remain, see electrical
- New exit sign, see electrical

NOTES

- ① NEW CEILING THIS AREA AND NEW FIXTURES THIS AREA
- ② COVERED PATIO
- ③ NEW CANOPY WITH T8 OUTDOOR LIGHTING FIXTURES, TYP. SEE ELECTRICAL

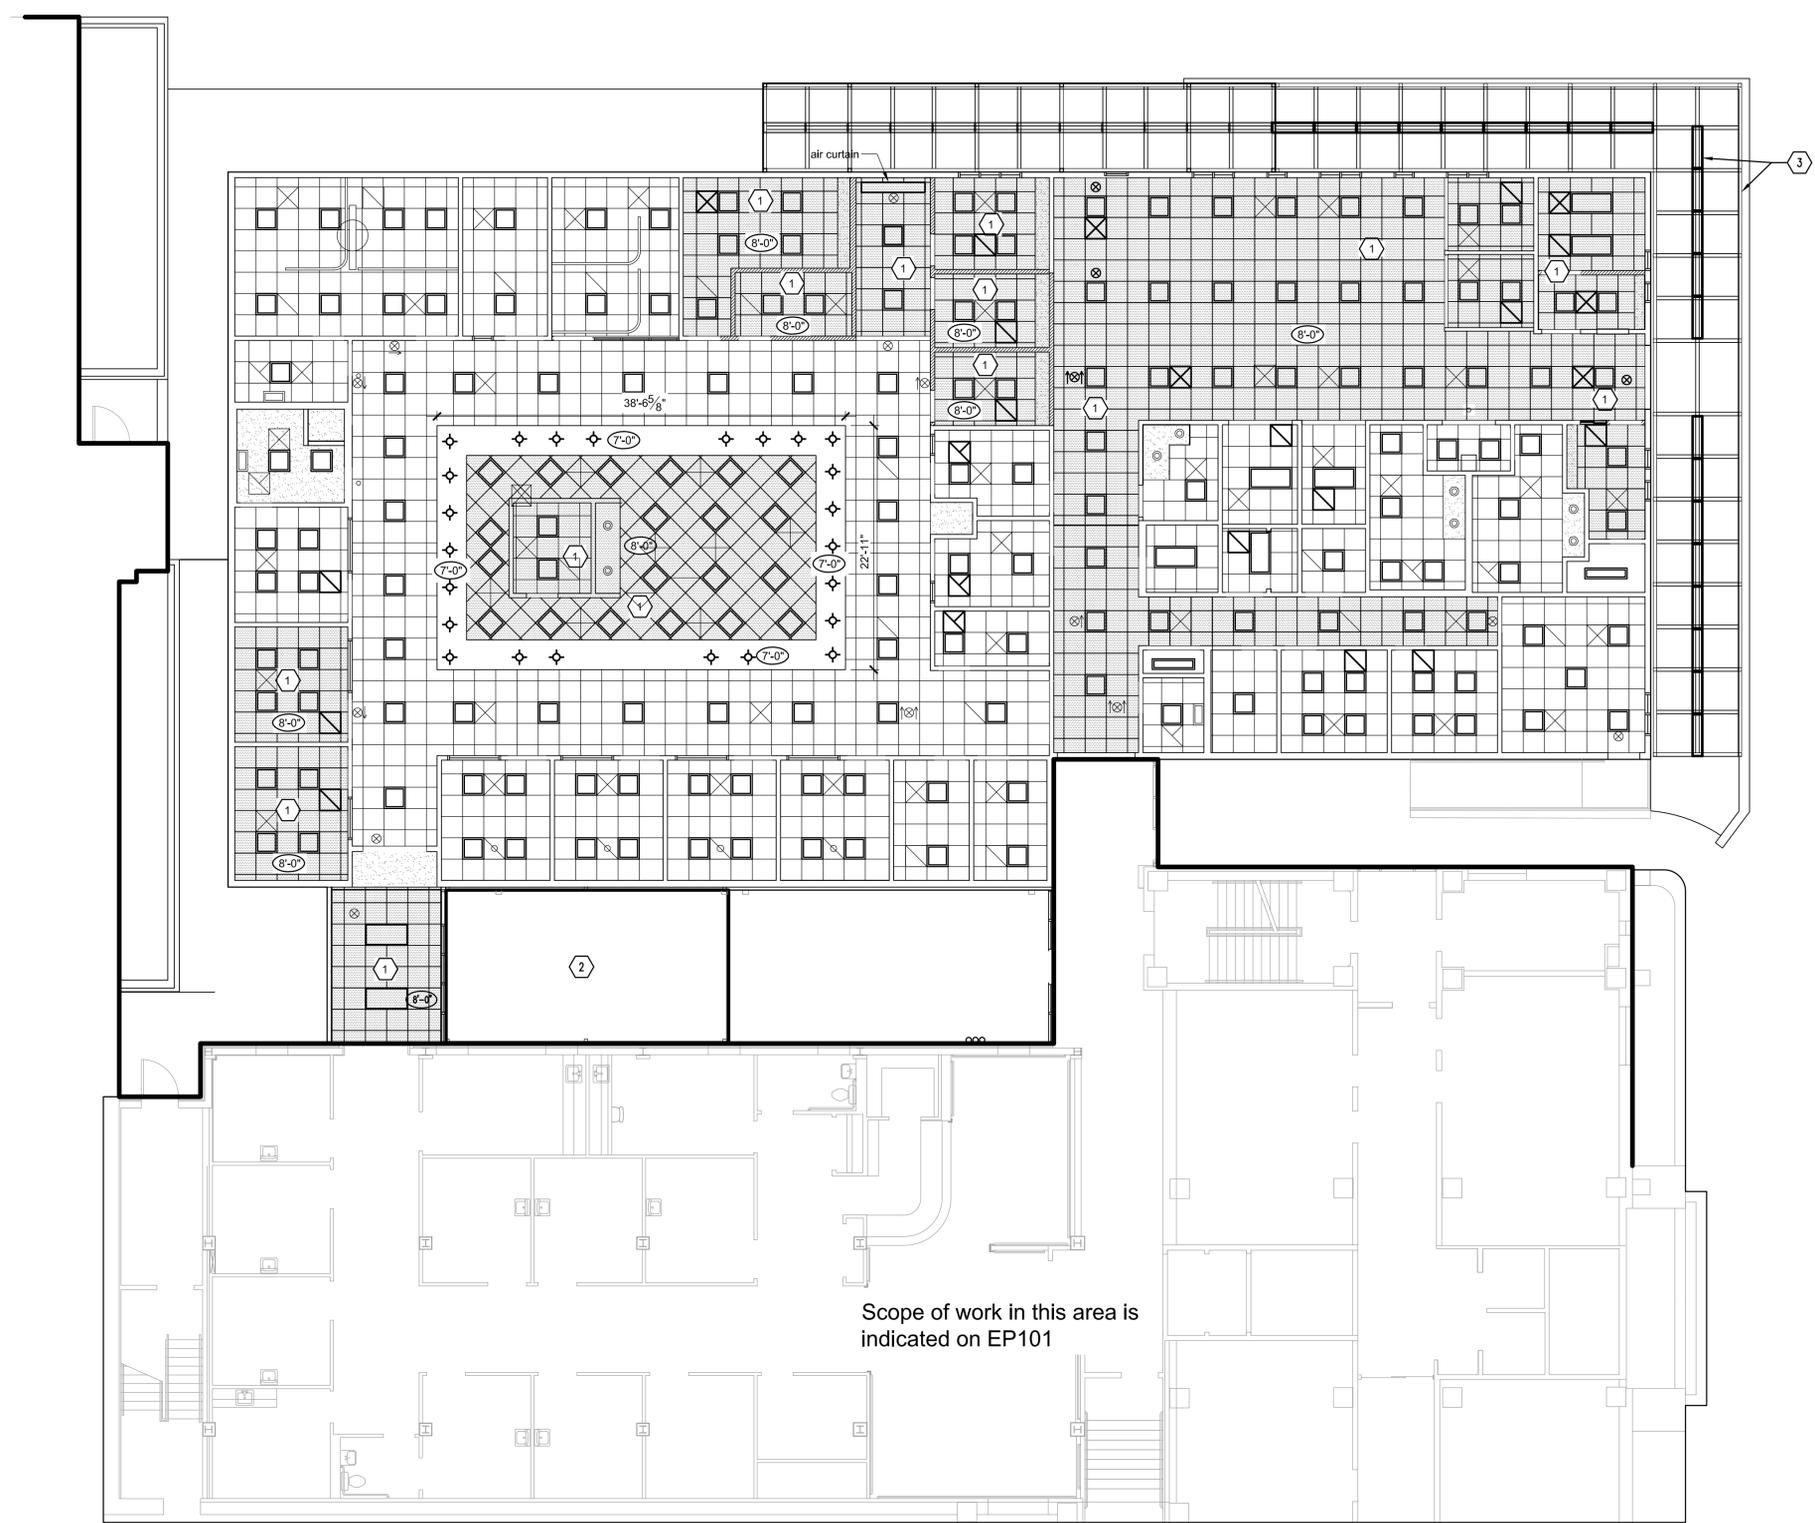

1 REFLECTED CEILING PLAN
D-2.0 SCALE: 1/8" = 1'-0"

Revisions		Remarks
No.	Date	

Approved: _____
Title _____ Signature _____

Approved: Service Engineer _____
Approved: Service Director _____

Project Title: **Reflected Ceiling Plan**

Project Name: **Southeast VA Health Care System (SLVHCS) A&E Design Urgent Care**

Project No.: VA256-C-0231

Building Number: _____ Checked: _____
S. Gonzalez

Location: 1601 Perdido Street, New Orleans, LA

Date: January 18, 2013

Project No.: VA256-C-0231

Revision No.: **A-4.0**

Dwg. 7 of 12

