




1 THIRD FLOOR PLAN - PROPOSED  
AS402 SCALE: 1/4" = 1'-0"

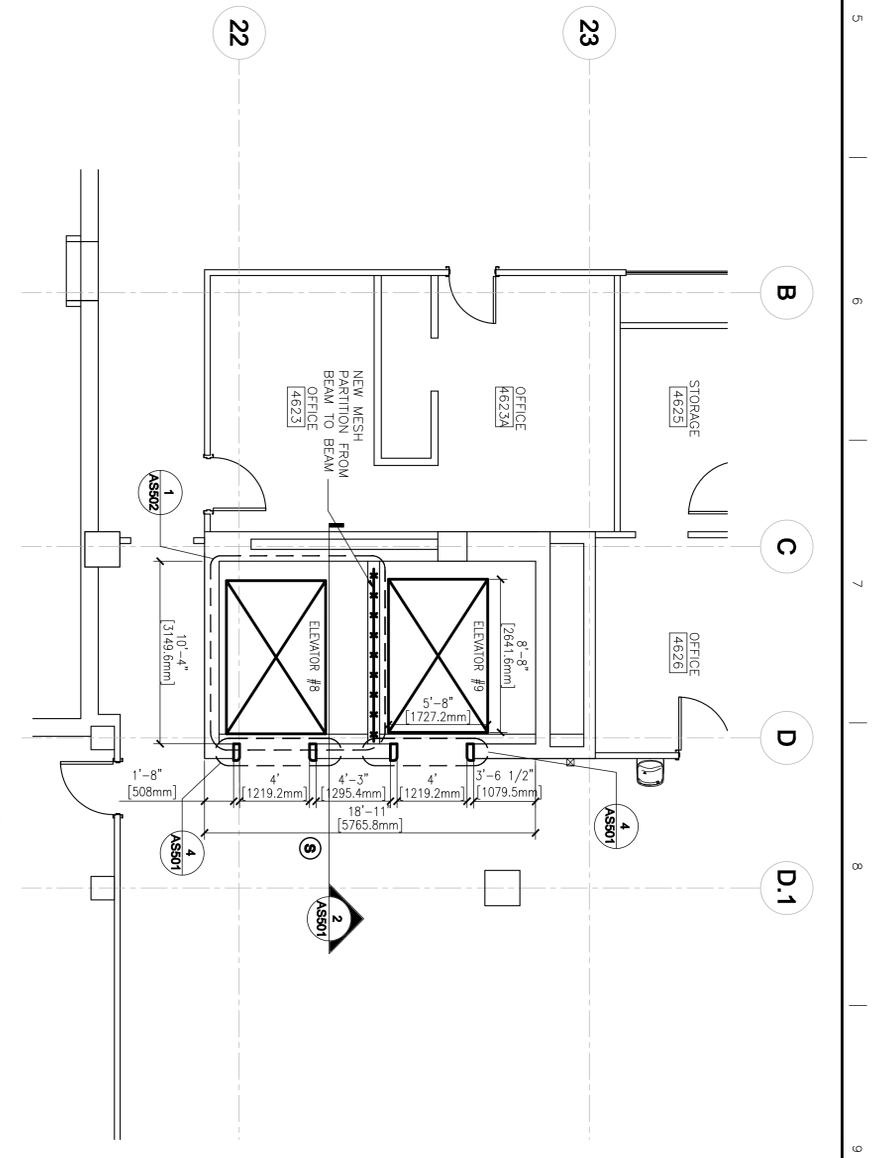

2 FOURTH FLOOR PLAN - PROPOSED  
AS402 SCALE: 1/4" = 1'-0"

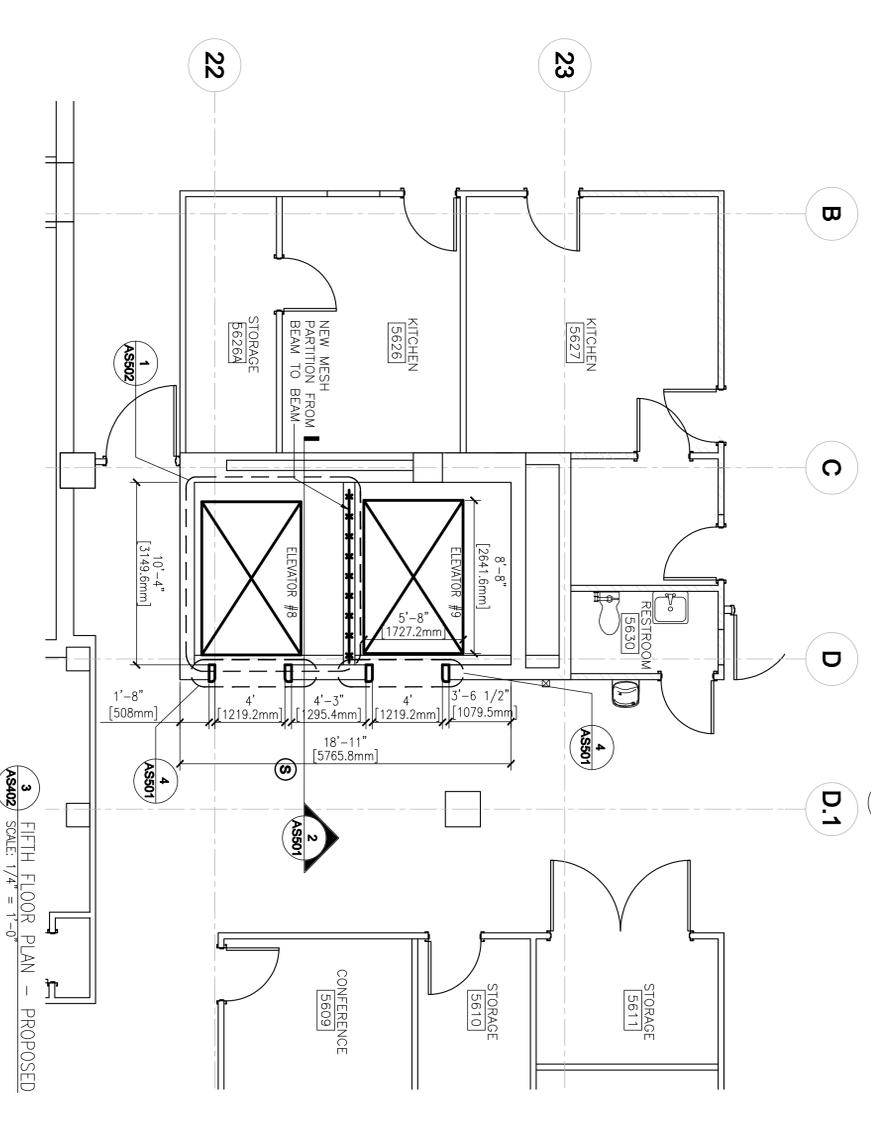

3 FIFTH FLOOR PLAN - PROPOSED  
AS402 SCALE: 1/4" = 1'-0"

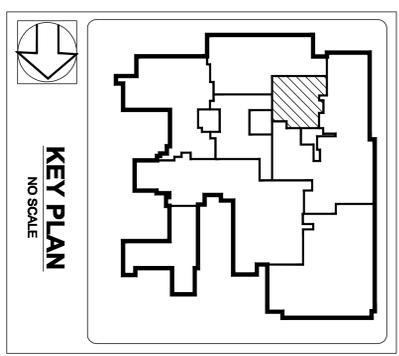

CONSULTANTS:

ARCHITECT/ENGINEERS:

**POND**  
Architects • Engineers • Planners  
Company • All rights reserved. No  
copying or distribution of drawings  
without written agreement of Pond  
& Company.  
Copyright © 2011 by Pond &  
Company. All rights reserved. No  
copying or distribution of drawings  
without written agreement of Pond  
& Company.

Drawing Title  
ENLARGED ELEVATOR CORE PLANS -  
3RD, 4TH AND 5TH FLOORS  
Approved: Project Director

Project Title  
Birmingham VA  
Replacement of Elevators  
Eight and Nine  
Location  
700 South 19th St. Birmingham, AL  
Date  
FEBRUARY 2, 2011  
Checked  
DRW  
Drawn  
DJH  
Project Number  
521-10-114  
Building Number  
1A  
Drawing Number  
AS402  
Dwg. 7 of 18

Office of  
Construction  
and Facilities  
Management  
Department of  
Veterans Affairs

READY TO ADVERTISE SUBMITTAL

Revisions:

Date

