




A three inches = one foot
 B one and one-half inch = one foot
 C one inch = one foot
 D three-quarters inch = one foot
 E one-half inch = one foot
 F three-eighths inch = one foot
 G one-quarter inch = one foot
 H one-eighth inch = one foot

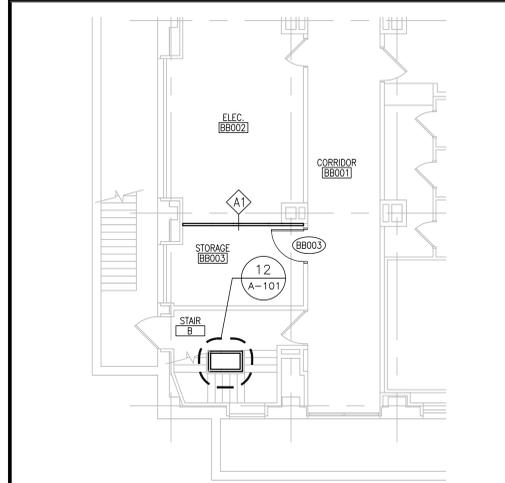


1 PARTIAL BASEMENT FLOOR PLAN
1/8" = 1'-0"

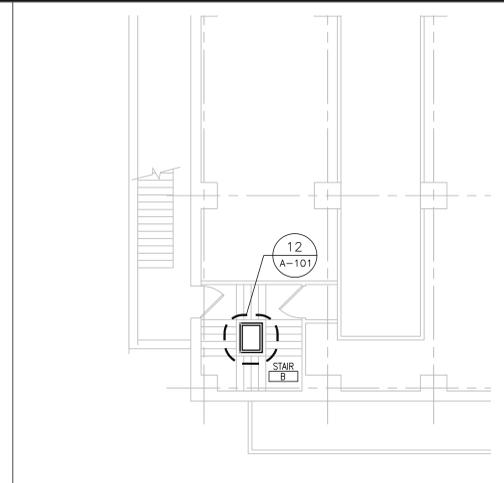


2 PARTIAL FIRST FLOOR PLAN
1/8" = 1'-0"

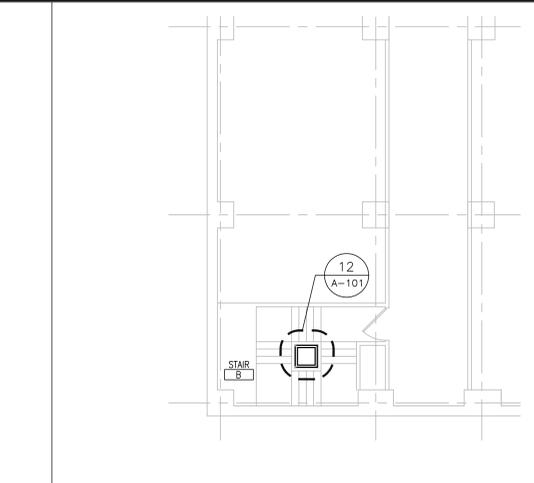


3 PARTIAL SECOND FLOOR PLAN
1/8" = 1'-0"

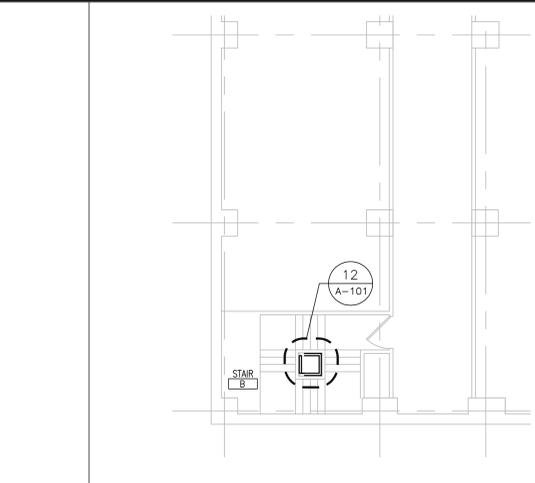


4 PARTIAL THIRD FLOOR PLAN
1/8" = 1'-0"

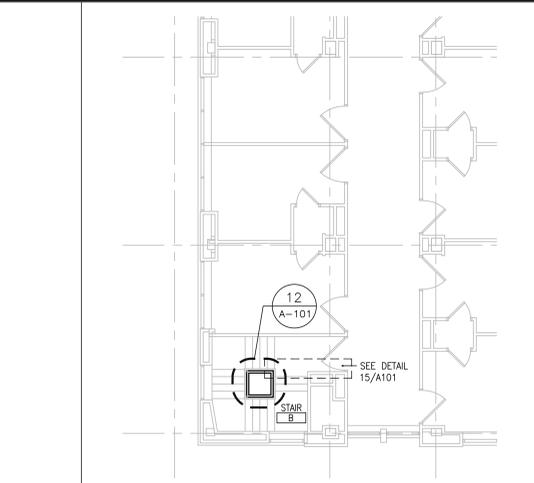


5 PARTIAL FOURTH FLOOR PLAN
1/8" = 1'-0"

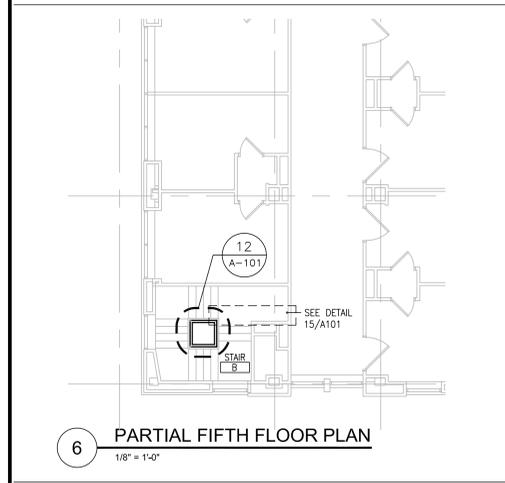


6 PARTIAL FIFTH FLOOR PLAN
1/8" = 1'-0"

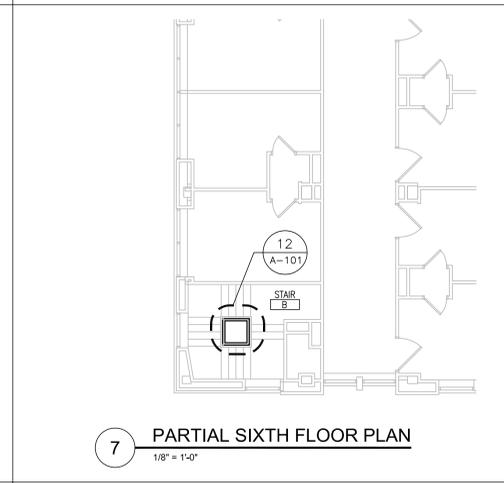


7 PARTIAL SIXTH FLOOR PLAN
1/8" = 1'-0"

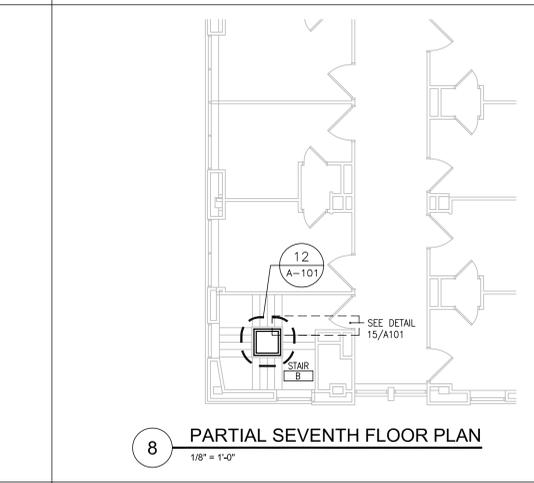


8 PARTIAL SEVENTH FLOOR PLAN
1/8" = 1'-0"

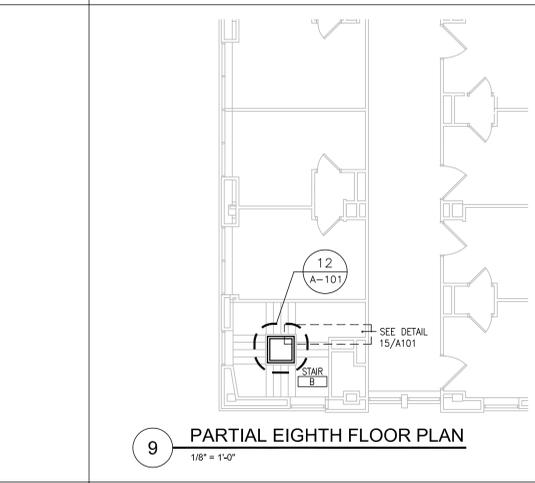


9 PARTIAL EIGHTH FLOOR PLAN
1/8" = 1'-0"

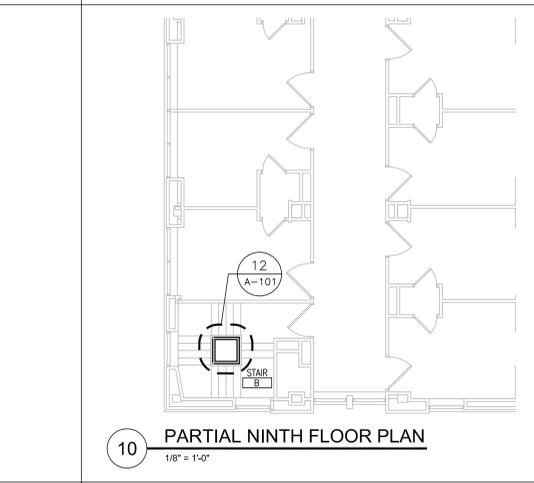


10 PARTIAL NINTH FLOOR PLAN
1/8" = 1'-0"

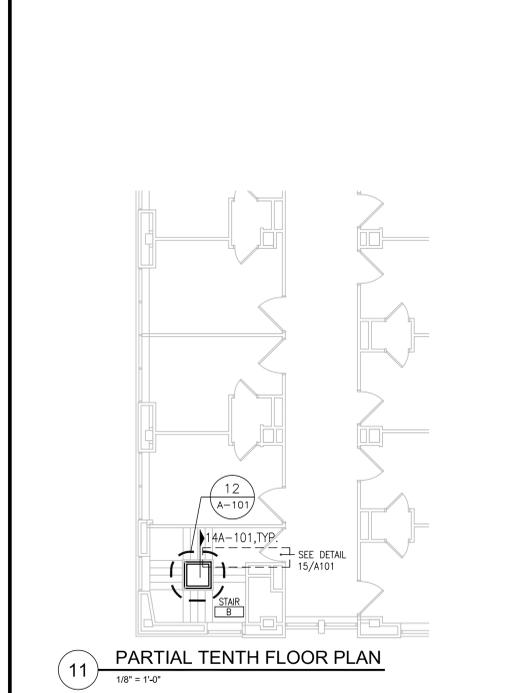


11 PARTIAL TENTH FLOOR PLAN
1/8" = 1'-0"

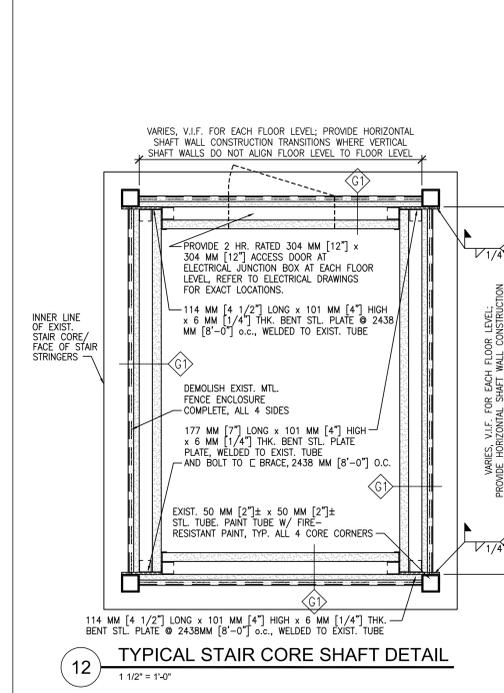


12 TYPICAL STAIR CORE SHAFT DETAIL
1 1/2" = 1'-0"

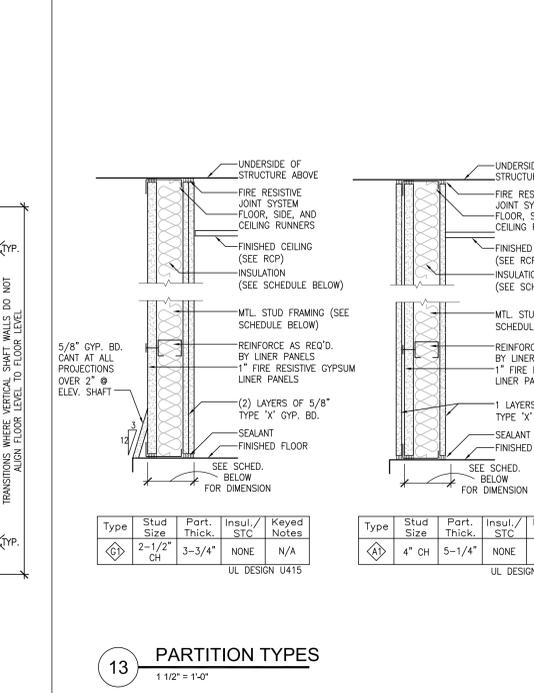

13 PARTITION TYPES
1 1/2" = 1'-0"

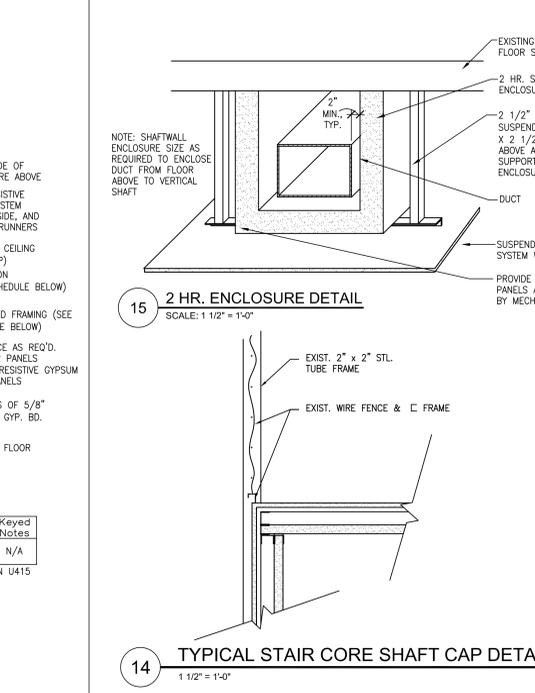

14 TYPICAL STAIR CORE SHAFT CAP DETAIL
1 1/2" = 1'-0"

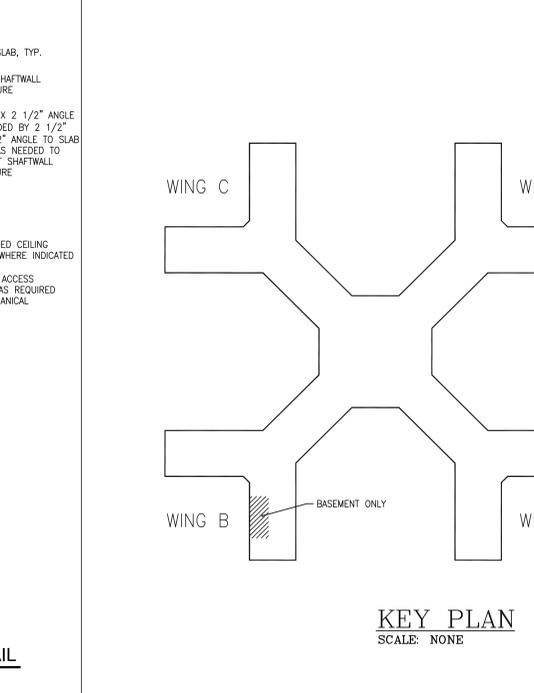

KEY PLAN
SCALE: NONE

Revisions	Date

VA WESTERN NEW YORK HEALTHCARE SYSTEM
 3495 BAILEY AVENUE
 BUFFALO, NEW YORK 14215

CANNONDESIGN
 2170 Whitehaven Road, Grand Island, New York 14072
 T: 716.773.6800 F: 716.773.5909
 Boston • New York • Baltimore • Washington DC •
 Buffalo • Toronto • Chicago • St. Louis • Phoenix • Calgary •
 Vancouver • Victoria • San Francisco • Los Angeles • Shanghai
 Architect

stamp

CARDIOLOGY MANAGER	DATE	ENGINEERING MANAGER	DATE
INFECTION CONTROL	DATE	CARELINE MANAGER	DATE
SAFETY OFFICER	DATE	CHIEF OF STAFF	DATE

Drawing Title
**PARTIAL FLOOR PLANS
 & STAIR CORE SHAFT
 DETAILS**

Project Title
**CRITICAL ELECTRICAL
 SYSTEM EXPANSION -
 WINGS B AND C**

Date
 September 14, 2012
 Station No.
 528-P-0168
12-104-A101
 LJA

