


A B C D E F G H J

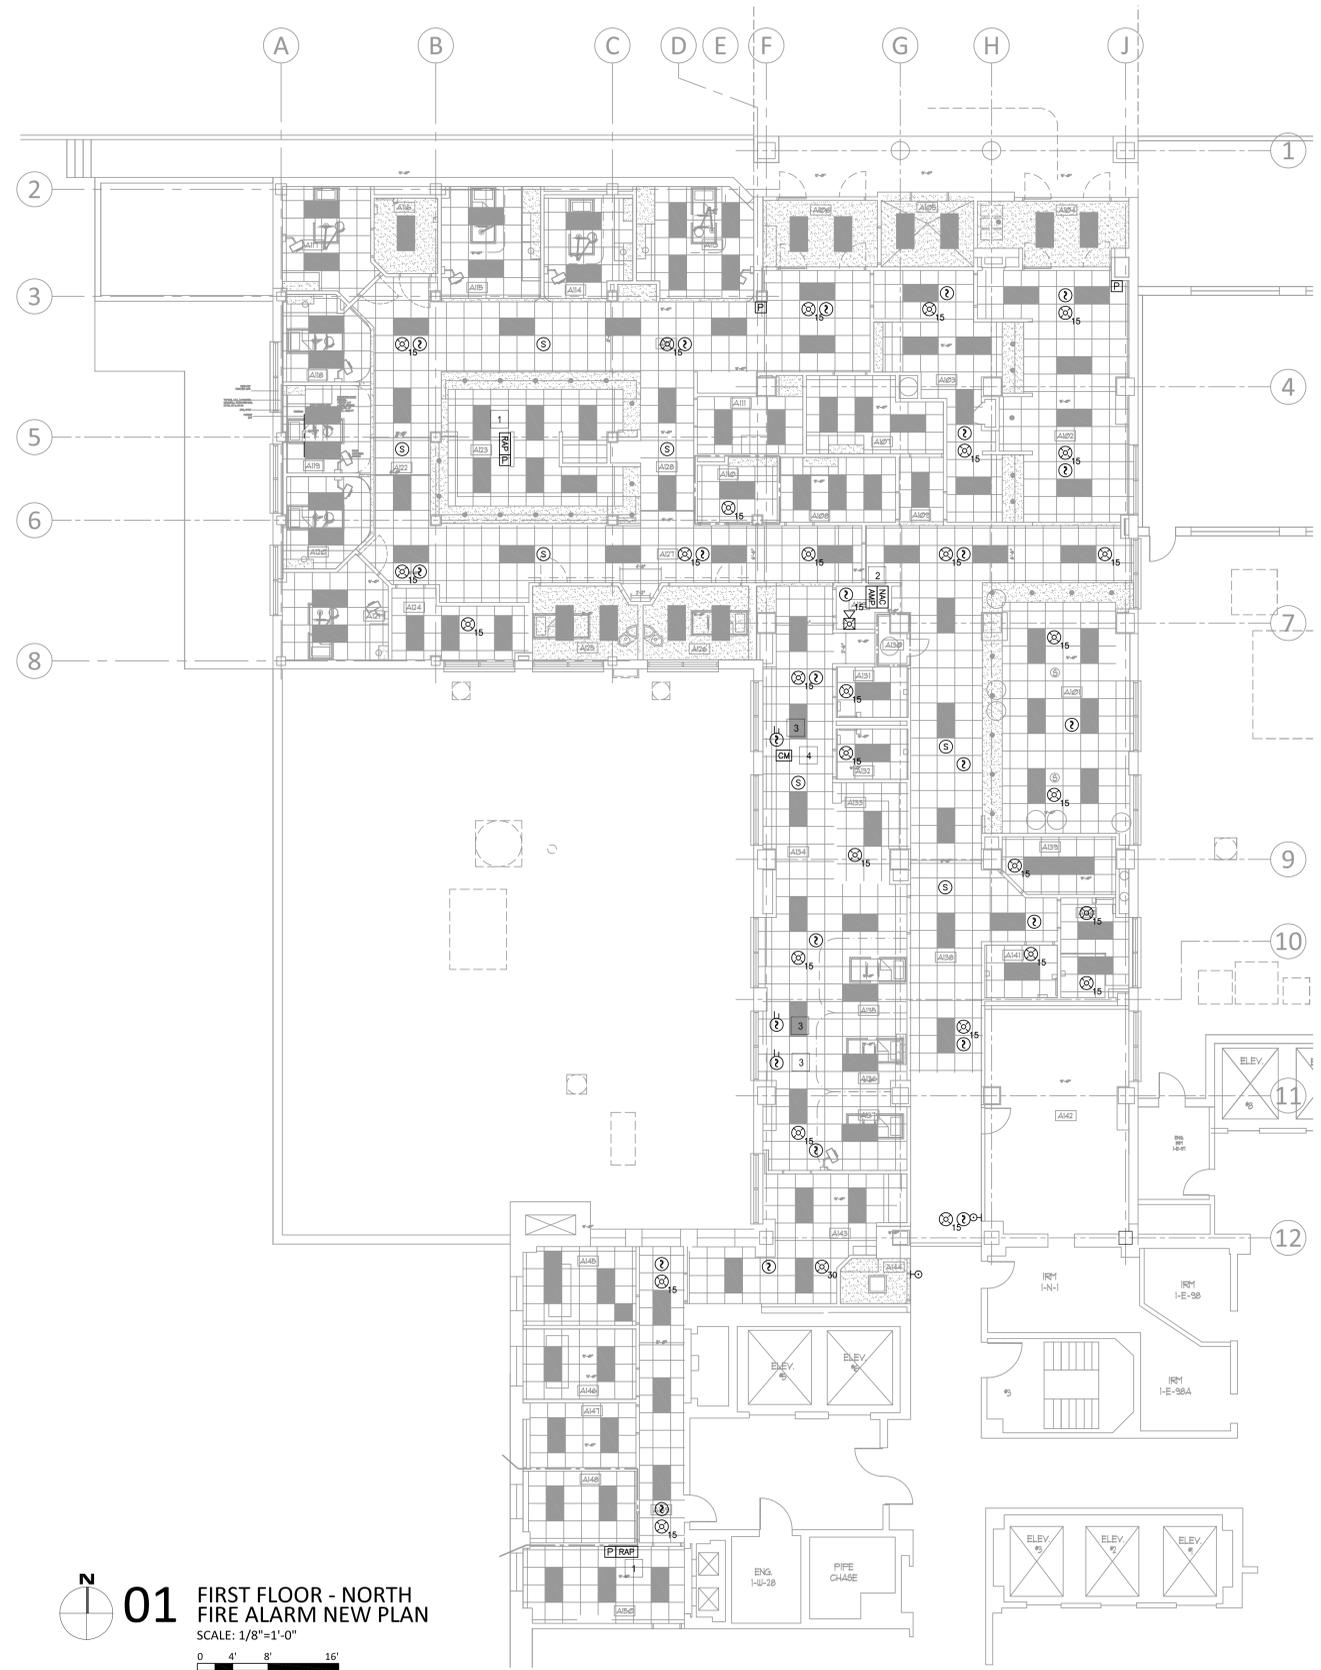

SHEET NOTES:

- SEE SHEET FA0.1 FOR SYMBOL LEGEND AND NOTES.
- INSTALL AREA SMOKE DETECTORS AND SMOKE ALARMS A MINIMUM OF 3 FEET FROM THE EDGE OF SUPPLY OR RETURN AIR DIFFUSERS.
- INSTALL CEILING MOUNTED FIRE ALARM DEVICES IN THE CENTER OF SUSPENDED CEILING TILES.
- THIS SHEET DEPICTS THE INTENT OF INSTALLATION ONLY. THIS SHEET MAY NOT SHOW ALL NECESSARY EQUIPMENT FOR A FULLY FUNCTIONAL FIRE ALARM SYSTEM. IT IS THE CONTRACTOR'S RESPONSIBILITY TO PROVIDE ALL NECESSARY EQUIPMENT / MATERIALS/ LABOR. PROGRAMMING TO PROVIDE A FULLY FUNCTIONAL SYSTEM THAT COMPLIES WITH THE APPLICABLE CODES.


KEYED NOTES:

- NEW REMOTE ANNUNCIATOR PANEL LOCATION. COORDINATE LOCATION WITH VA.
- POTENTIAL LOCATION FOR NOTIFICATION APPLIANCE CIRCUIT POWER PANEL AND DISTRIBUTED AMPLIFIER. COORDINATE LOCATION WITH VA.
- DUCT SMOKE DETECTOR SERVING DUCTWORK FOR AHU-1N.
- ADDRESSABLE CONTROL MODULE FOR INTERFACE WITH AHU-1N FOR SHUTDOWN UPON ACTUATION OF DUCT SMOKE DETECTOR.

three inches = one foot
 one and one half inches = one foot
 one inch = one foot
 three quarters inch = one foot
 one half inch = one foot
 three eighths inch = one foot
 one quarter inch = one foot
 one eighth inch = one foot

01 FIRST FLOOR - NORTH FIRE ALARM NEW PLAN
 SCALE: 1/8"=1'-0"
 0 4' 8' 16'
 1/8"=1'-0"

KEYPLAN: FIRST FLOOR

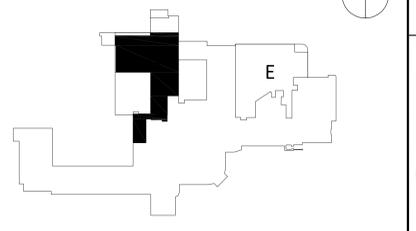

FULLY SPRINKLERED
 Scale: AS NOTED

Revisions	Date

CONSULTANTS:

The Estopinal Group
 CONSULTANTS

HUGHES ASSOCIATES, INC.
 FIRE PROTECTION ENGINEERS
 CODE CONSULTANTS

820 Jordan Street, Suite 507 tel. 318.424.3700
 Shreveport, LA 71101 fax 318.424.3764

2121 W. Spring Creek Parkway, Suite 108
 Plano, Texas 75023 Phone: 972-491-1900

PROJECT MANAGERS AND ENGINEERS:

TNF A VETERAN OWNED COMPANY

3 EXECUTIVE COURT, UNIT 4
 SOUTH BARRINGTON, IL 60010

Drawing Title	FIRST FLOOR - NORTH FIRE ALARM NEW PLAN
Approved Project Director	

Project Title	RENOVATE ED + PRIMARY CARE	Project Number	667-10-100
Location	SHREVEPORT VAMC 510 EAST STONER AVE	Building Number	1N, 1E
Date	01/09/13	Drawing Number	FA1.N1
Checked	SU	Drawn	MP
		Dwg. 109 of 112	

Office of Construction and Facilities Management
 Department of Veterans Affairs