

VA FORM 08-6231, OCT 1978

Revisions:	Date
ISSUED FOR PERM	05-23-13
FINAL CD SUBMISSION	12-21-12
95% SUBMISSION	11-30-12
65% SUBMISSION	11-16-12

CONSULTANTS:



FREDERICK, FREDERICK & HEILLER
ENGINEERS, INC.
872 EAST ROYALTON ROAD
BROADVIEW HTS., OHIO 44147
PH: (440) 946-8888





ARCHITECT:



PARTIAL PENTHOUSE - STEAM PIPING - AREA 1

1

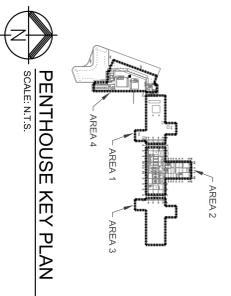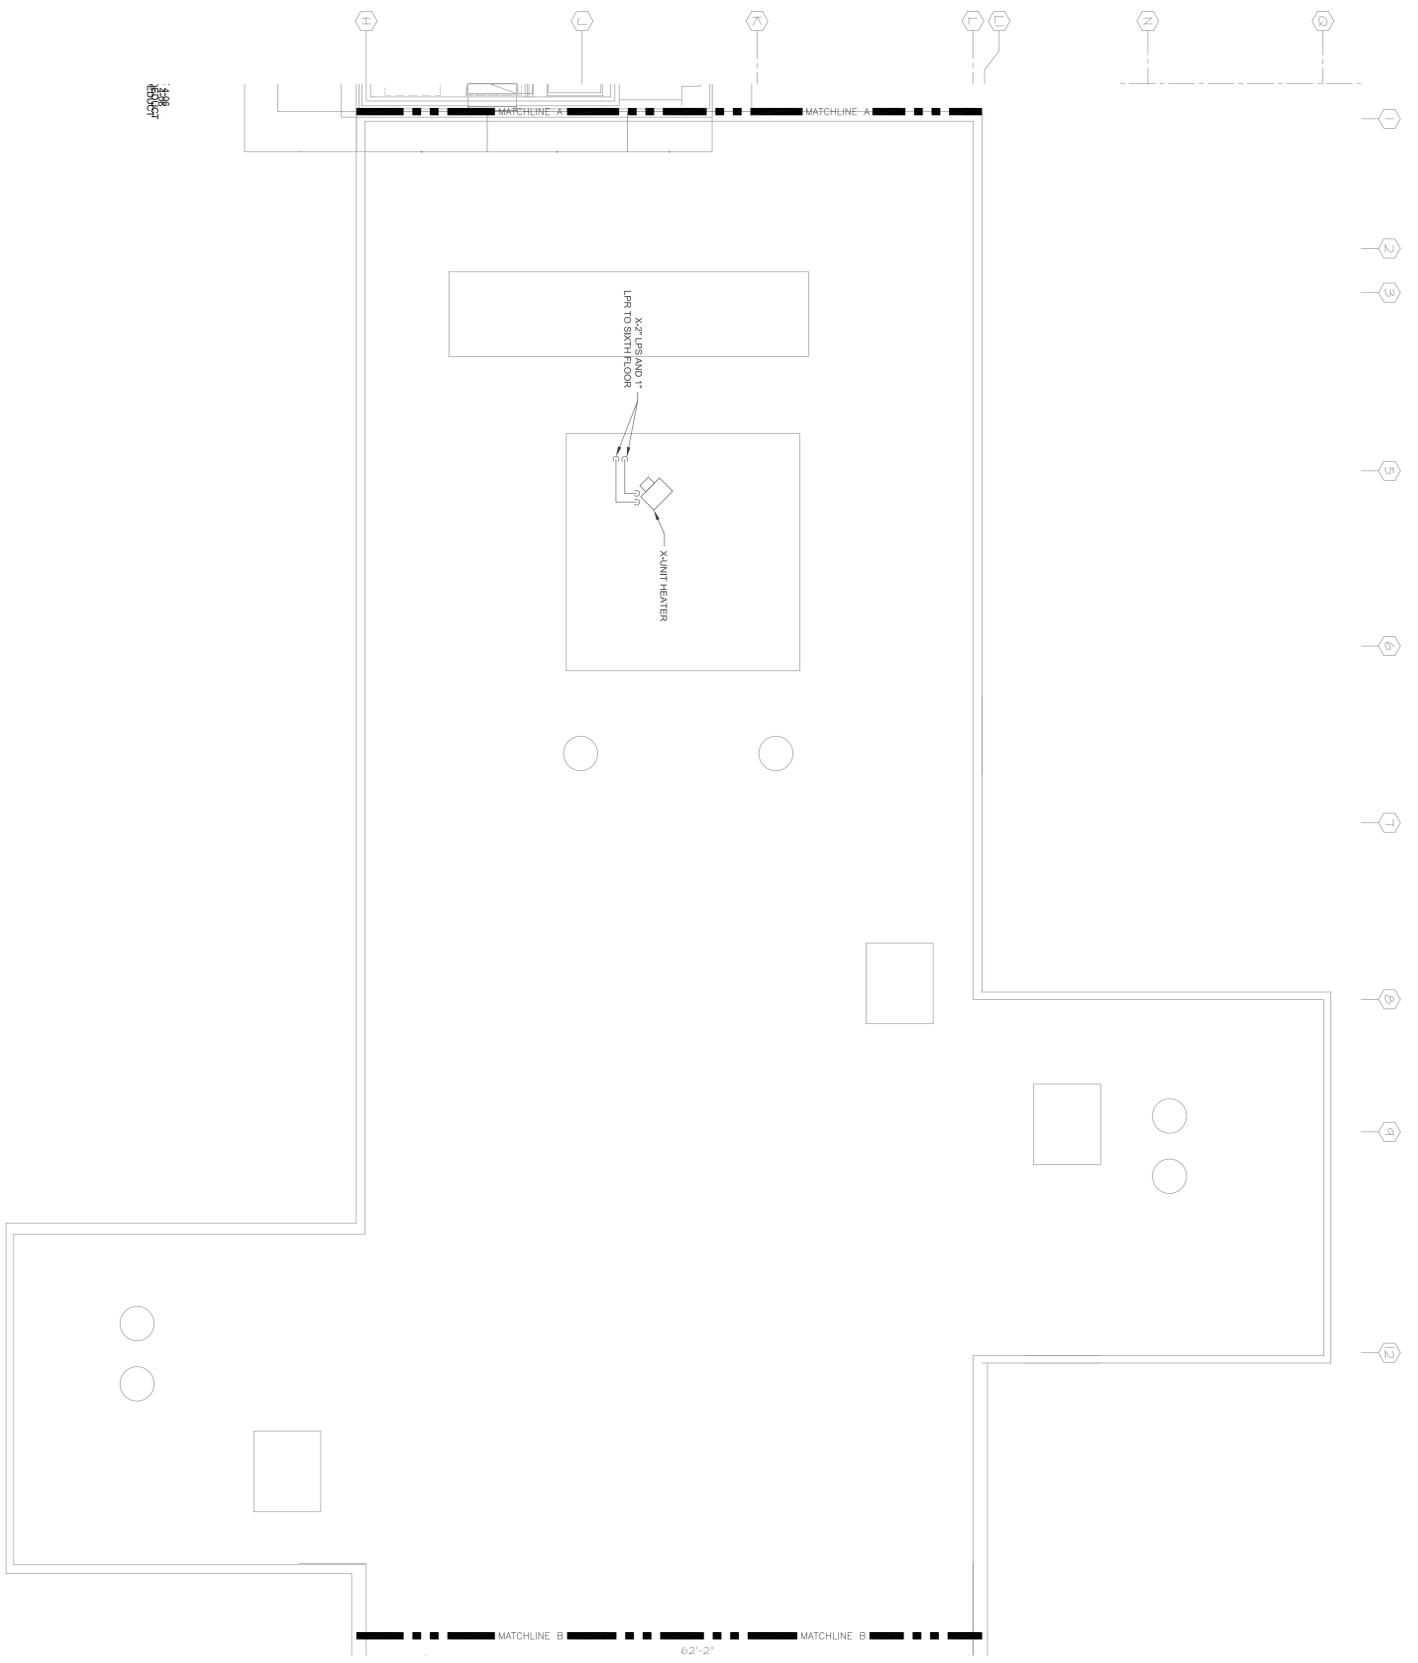

Drawing Title PARTIAL PENTHOUSE STEAM PIPING PLAN - AREA 6		Project Title STEAM TRAP MONITORING, INSULATION AND PIPING UPGRADES		Project Number 641-12-115	
Approved: Project Director		Location VAMC - WADE PARK		Building Number 1	
Date 12-21-12		Checked WFW		Drawing Number 3-PH-1	
Drawn JMF		Office of Facilities Management			

