



1 | 2 | 3 | 4 | 5 | 6 | 7 | 8

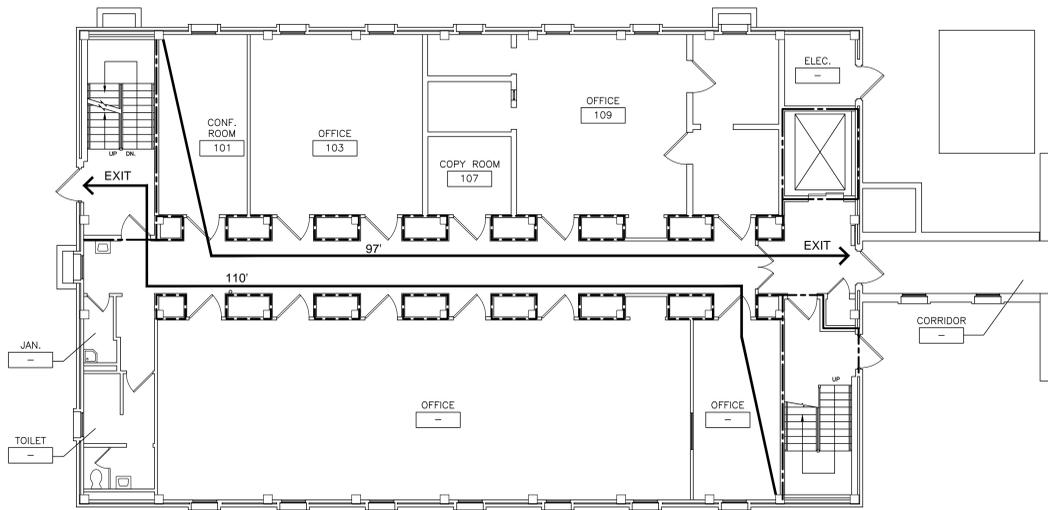

1 LIFE SAFETY PLAN - FIRST FLOOR  
 U.S.-1 SCALE: 1/4" = 1'-0"

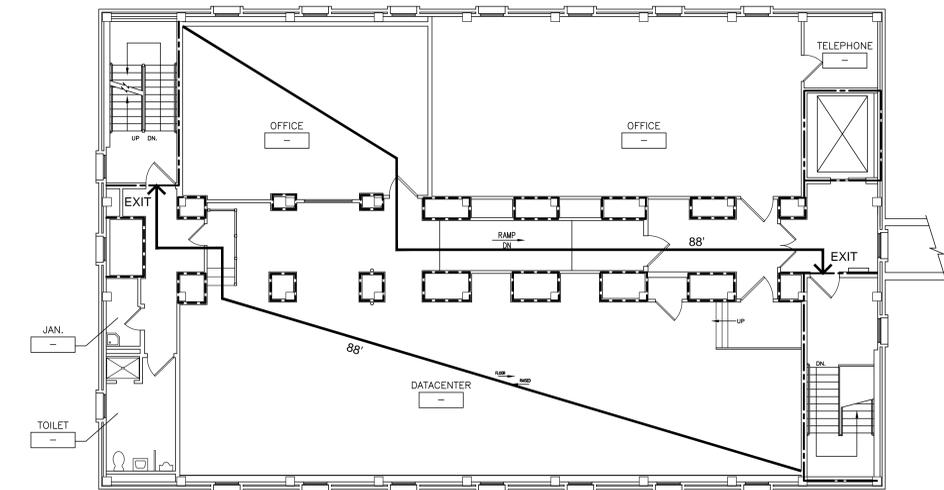

2 LIFE SAFETY PLAN - SECOND FLOOR  
 U.S.-1 SCALE: 1/4" = 1'-0"

<b>BUILDING CODE STUDY DATA</b>	
BUILDING OCCUPANCY - BUSINESS (B)	
APPLICABLE CODES	
FIRE/LIFE SAFETY: NFPA 101 2009	
<b>BUILDING NO. 15</b>	
EXISTING RENOVATED CONSTRUCTION - FIRST FLOOR:	4,625 GSF
EXISTING RENOVATED CONSTRUCTION - SECOND FLOOR:	4,625 GSF
<b>TOTAL RENOVATED CONSTRUCTION:</b>	<b>9,250 GSF</b>
<b>FIRE PROTECTION SYSTEMS:</b>	
AUTOMATIC SPRINKLERS (FULLY SPRINKLERED)	EXISTING YES
PORTABLE FIRE EXTINGUISHERS	YES
FIRE ALARM SYSTEM	YES

<b>GENERAL LEGEND</b>	86'	EGRESS PATH - TRAVEL DISTANCE
		1 HOUR RATED FIRE AND SMOKE
		2 HOUR RATED FIRE AND SMOKE
		FIRE EXTINGUISHER CABINET
		FIRE EXTINGUISHER

three inches = one foot  
 one and one-half inch = one foot  
 one inch = one foot  
 three-quarters inch = one foot  
 one-half inch = one foot  
 three-eighths inch = one foot  
 one-quarter inch = one foot  
 one-eighth inch = one foot

A  
 B  
 C  
 D  
 E

100% SUBMISSION FOR REVIEW

<p><b>Additions:</b></p> <table border="1" style="width: 100%; height: 40px;"> <tr><td> </td><td> </td></tr> <tr><td> </td><td> </td></tr> <tr><td> </td><td> </td></tr> </table> <p><b>Revisions:</b></p> <table border="1" style="width: 100%; height: 40px;"> <tr><td> </td><td> </td></tr> <tr><td> </td><td> </td></tr> <tr><td> </td><td> </td></tr> </table>													<p><b>Consultants</b></p> <p><b>BURDETTE KOEHLER MURPHY &amp; ASSOCIATES, INC.</b>                  MECHANICAL / ELECTRICAL CONSULTING ENGINEERING                  1423 CLARKVIEW ROAD, SUITE 500                  BALTIMORE, MARYLAND 21209                  410.323.9600 - FAX 410.377.2543</p>	<p><b>BUILDING COST CONSULTANTS</b>                  COST ESTIMATING                  12917 - 30TH AVENUE                  PLATTSMOUTH, NEBRASKA 68048                  402.298.8260 - FAX 402.298.8290</p>	<p><b>Seal:</b></p>	<p><b>ARCHITECTURE PLANNING ENGINEERING</b></p> <p><b>POLT DESIGN GROUP</b>                  1301 Enterprise Court, Suite 103-C Bel Air, Maryland 21014-1847                  410.803.2141 fax 410.838.1603                  www.polt-design.com</p>	<p><b>Drawing Scale:</b></p> <p><b>Drawing Start Date:</b></p> <p><b>Drawing Finish Date:</b></p> <p><b>Drawing Approved:</b></p>	<p><b>Drawing Title:</b>                  LIFE SAFETY PLAN - FIRST FLOOR</p> <p>Approved: Associate Director for Operations:</p> <p>Approved: Chief, Facilities Engineer:</p> <p>Approved: Director, Medical Center:</p>	<p><b>Project Title:</b>                  BUILDING 15 RENOVATION</p> <p>Building No: <b>15</b></p> <p>Checked: <b>CAJ</b></p> <p>Drawn: <b>BMH</b></p> <p>Location: <b>VAMHCS MEDICAL CENTER WILMINGTON, DELAWARE</b></p>	<p><b>Date:</b>                  12-19-2012</p> <p><b>Project No:</b>                  460-11-116</p> <p><b>DRAWING NO.:</b>                  LS-1</p> <p>Dwg. 2 of 46</p>

1 | 2 | 3 | 4 | 5 | 6 | 7 | 8

