



**PARTIAL 11TH WEST FLOOR PLAN -
NEW FLOOR PLAN**

SCALE: 1/8" = 1'-0"


SPRAY ON FIRE PROOFING

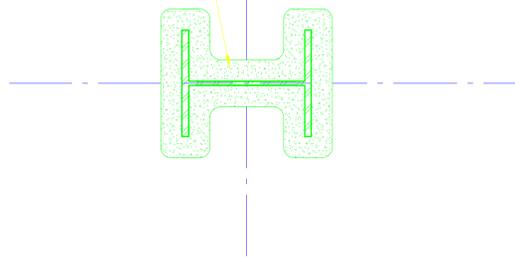

1 DETAIL
SCALE: 1/8" = 1'-0"

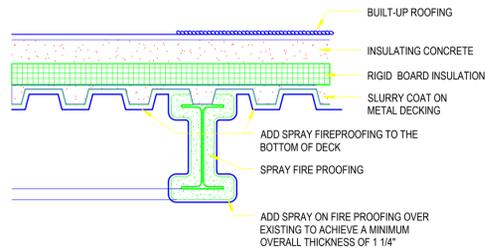

2 DETAIL
SCALE: 1/8" = 1'-0"

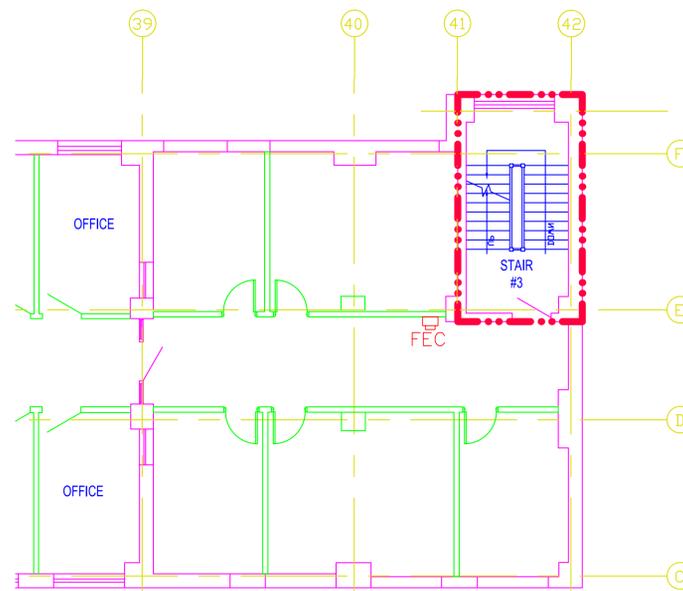

**PARTIAL 11TH EAST FLOOR PLAN -
NEW FLOOR PLAN**


SCALE: 1/8" = 1'-0"

LIFE SAFETY KEY

- 1 HR. SMOKE PARTITION
- 2 HR. RATED PARTITION
- FEC FIRE EXTINGUISHER WITH WALL CABINET

GENERAL NOTES

1. MAINTAIN FIRE RATING AT EXISTING COLUMNS. PATCH AND REPAIR FIREPROOFING MATERIAL - MATCH EXISTING.

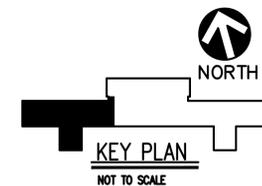

LEVEL 1 DESIGN
NOT FOR CONSTRUCTION

REVISIONS:	DATE



VAPHCS - UD
University Drive
Pittsburgh, PA 15240



APPROVED: DIRECTOR	APPROVED: VP, FACILITIES MANAGEMENT
APPROVED: ASSOCIATE DIRECTOR	APPROVED: CHIEF, PROJECTS SECTION
APPROVED: CHIEF OF STAFF	APPROVED: PROJECT ENGINEER
RESERVED	

DRAWING TITLE: FIRE PROTECTION- SMOKE ZONES	
PROJECT NO. RESERVED	CONTRACT NO. RESERVED
BUILDING NO. RESERVED	AUTOCAD FILE NAME: R:\Projects\VA University Drive (08047 - East Side) Drawing(08047 12-1.dwg

PROJECT TITLE: RENOVATE 11 WEST		
DESIGNED BY: HHH	DRAWN BY: HHH	CHECKED BY: RESERVED
LOCATION: VAMC UNIVERSITY DR. PITTSBURGH, PA		

DATE: 8/27/2012
SCALE: 1/8" = 1'-0"
DRAWING NO. FA-2

DEPARTMENT OF
VETERANS AFFAIRS