
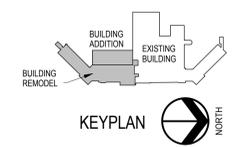


FIRE SPRINKLER KEYNOTES

- 1 REMOVE EXISTING FIRE SPRINKLER BACK TO MAINS. INSTALL NEW PIPING, FLOW SWITCH AND VALVES FOR EXPANDED FIRE PROTECTION ZONE. DEMOLITION WORK TO OCCUR AFTER HOURS TO PREVENT DISRUPTION TO THE MEDICAL CENTER.
- 2 PROVIDE NEW FIRE PROTECTION SPRINKLER ZONE WITH PIPING, FLOW SWITCH AND VALVES.
- 3 REMOVE AND REPLACE FIRE PROTECTION SPRINKLER SYSTEM IN REMODEL AREA TO PROVIDE 100% COVERAGE.
- 4 ORDINARY HAZARD GROUP 1 AREA.
- 5 NEW F.P. SPRINKLER PIPING TO NEW CONSTRUCTION AREA.

NOTE: NOT ALL KEYNOTES MAY BE USED ON EACH PLAN.

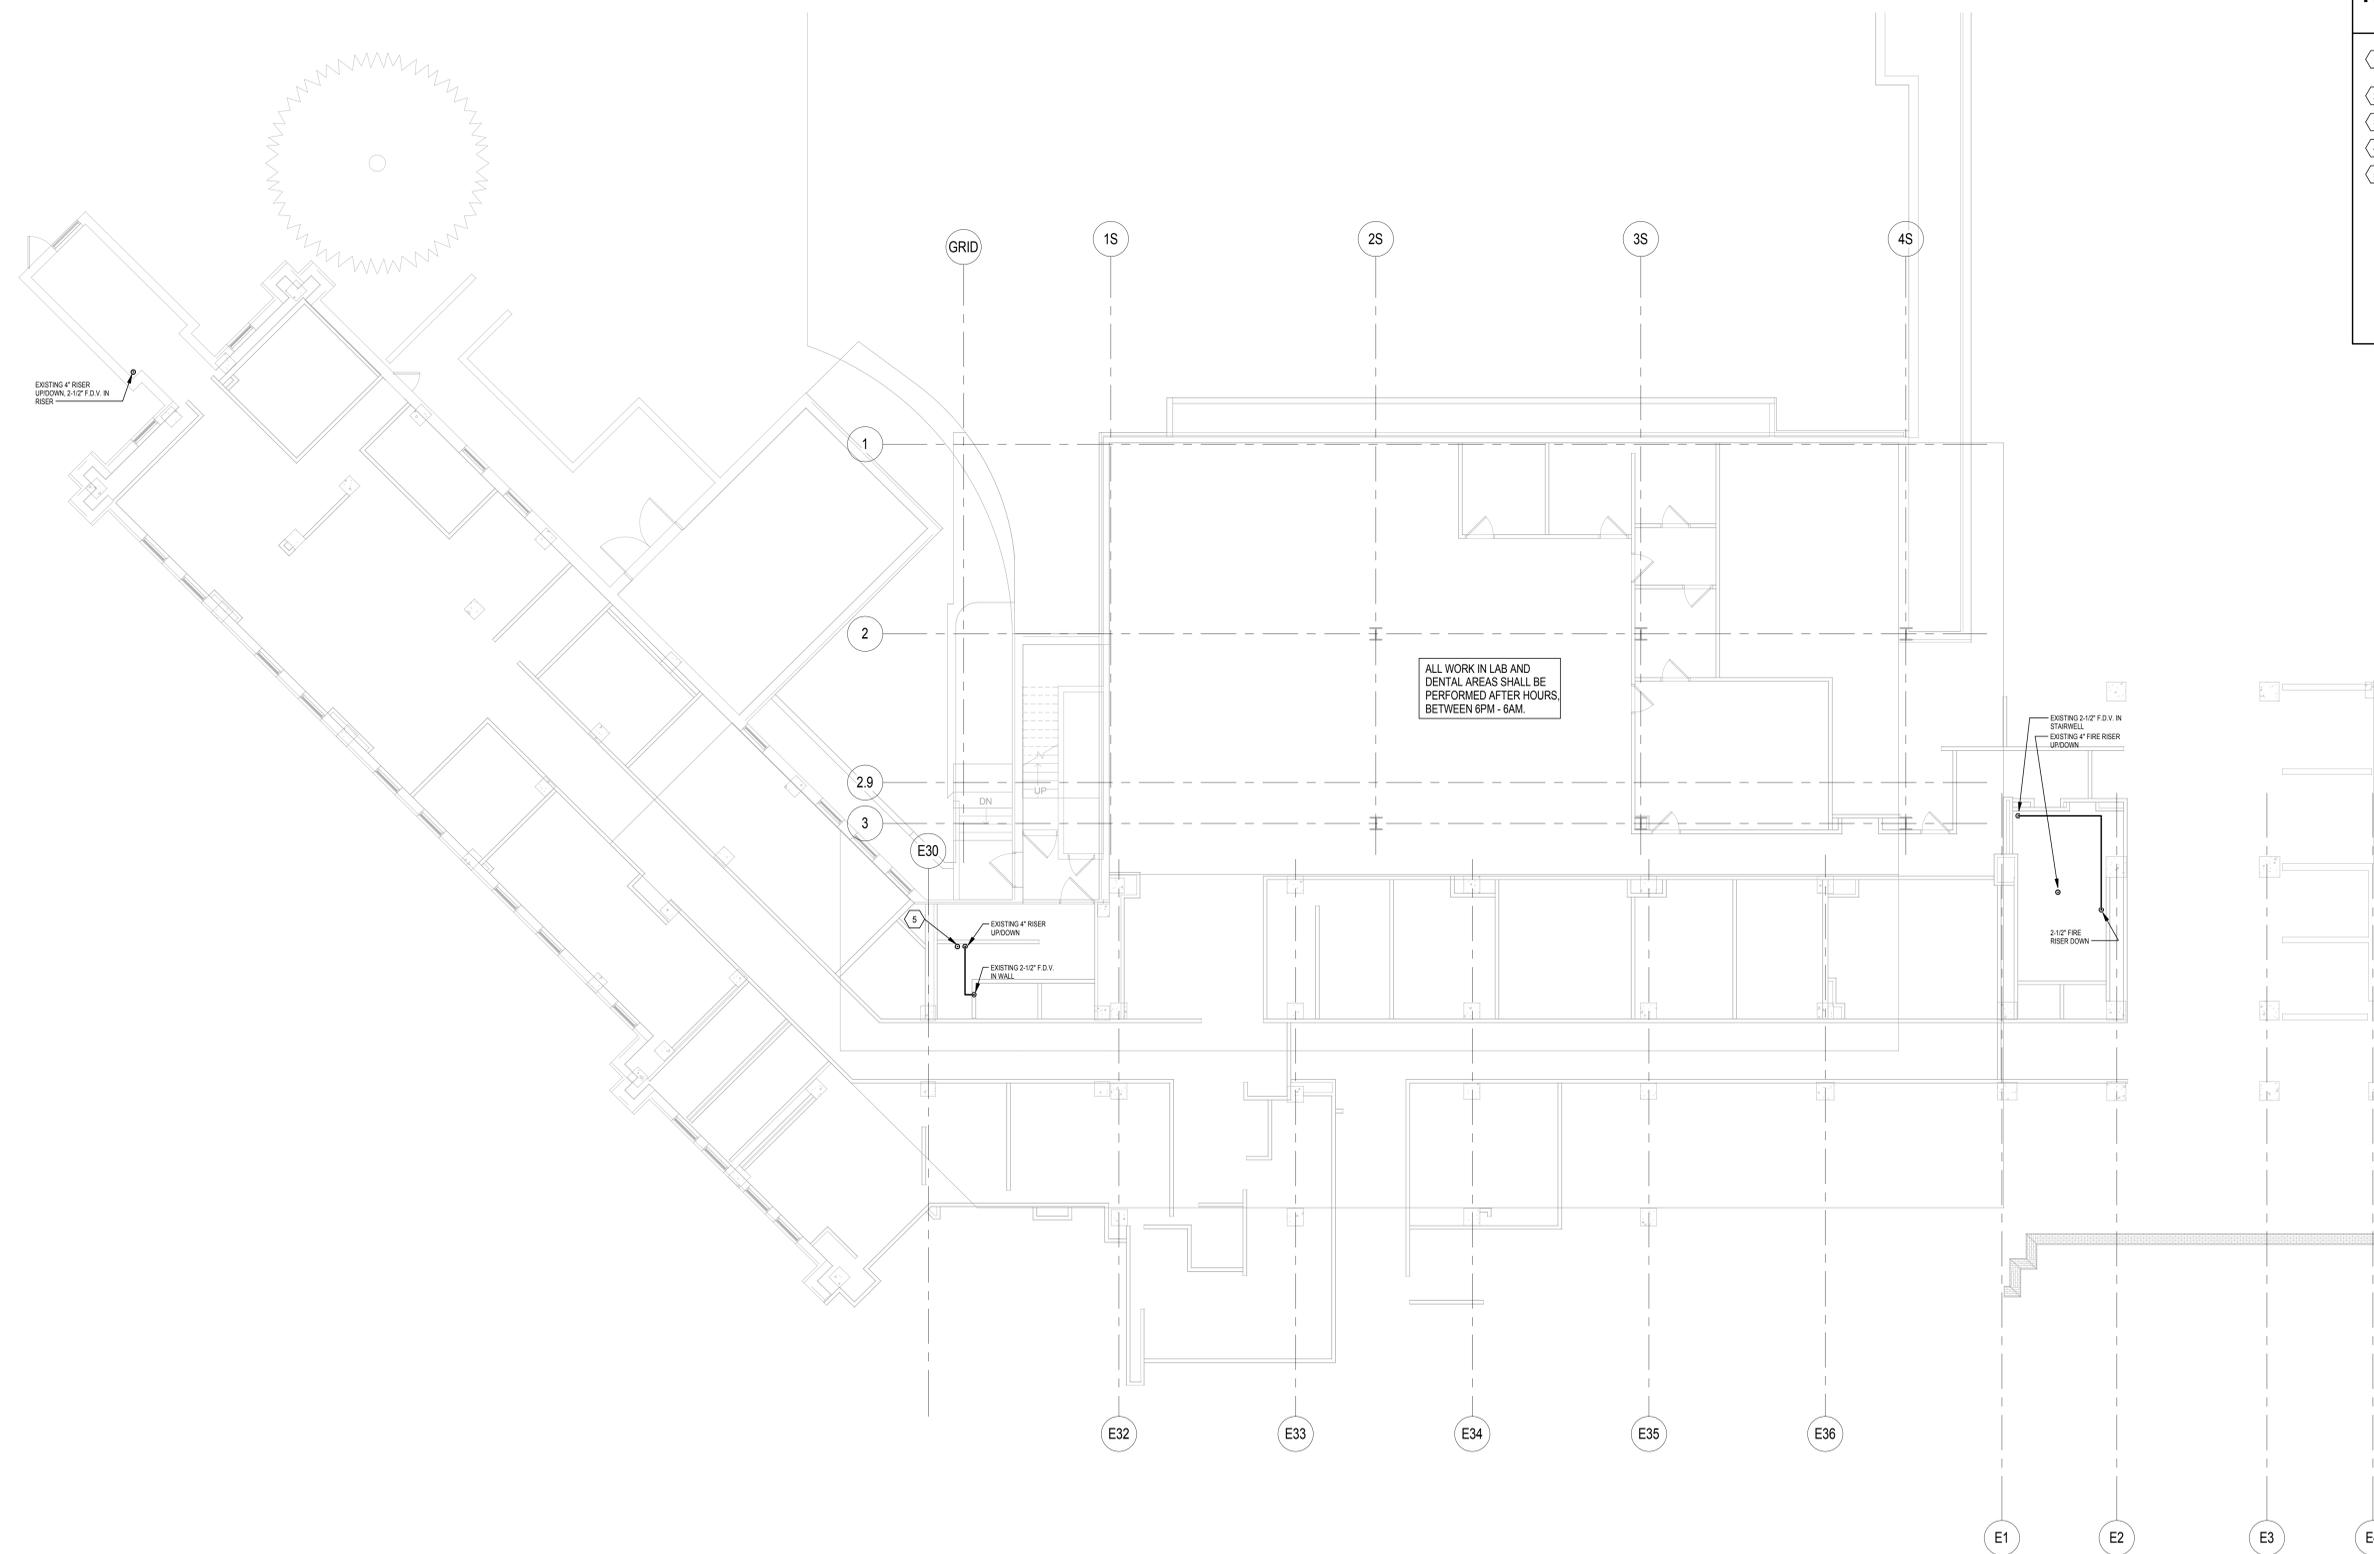

1F GROUND FLOOR FIRE SUPPRESSION PLAN
1/8" = 1'-0"

**FULLY SPRINKLERED
100% CONSTRUCTION DOCUMENTS**

<table border="1"> <thead> <tr> <th>MARK</th> <th>REVISION DESCRIPTION</th> <th>DATE</th> </tr> </thead> <tbody> <tr> <td> </td> <td> </td> <td> </td> </tr> </tbody> </table>	MARK	REVISION DESCRIPTION	DATE				<p>CONSULTANTS:</p>		<p>ARCHITECTS/ ENGINEERS:</p> <p>TSP, Inc. 1112 N. West Ave. Sioux Falls, SD 57104 phone: (605) 336-1160 fax: (605) 336-7926 www.teamtsp.com</p> <p>To Solve. To Excel. Together.</p>	<p>Drawing Title GROUND FLOOR FIRE SUPPRESSION PLAN</p>	<p>Project Title Sioux Falls VA Health Care System Acute Inpatient Medical Unit Addition and Renovation</p>	<p>Project Number 04100857</p>	<p>Office of Construction and Facilities Management</p>
	MARK	REVISION DESCRIPTION	DATE										
<p>Approved: Project Director</p>	<p>Location VA Medical Center 2871 W. 22nd Street, PO Box 9046 Sioux Falls, SD 57117-9046</p>	<p>Building Number 5</p>	<p>Date 08/06/2012</p>	<p>Checked BSW</p>	<p>Drawn RAK</p>	<p>Drawing Number 5-FX100 Dwg. 53 of 123</p>							

C:\Users\craig\Documents\04100857_VA_MEP12_Central_cooling.plt 8/6/2012 12:00:03 PM