
 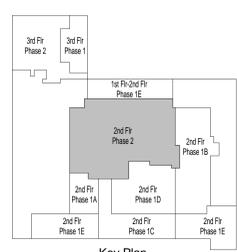


Sheet Notes

- All door locations in gypsum board partitions not dimensioned will be 4" from the studs of perpendicular wall to door edge (U.N.O.).
- All dimensions are from face-of-stud, face of concrete, or center of framed opening, unless noted otherwise.
- For dimensions of masonry walls and rough openings, see the Structural drawings. Masonry dimensions shown on this plan are for reference only. Any discrepancies found between the dimensions on this sheet and the Structural drawings shall be brought to the immediate attention of the Architect.
- Provide 6" wide, 24 gage flat strap blocking behind all fixtures and wall mounted accessories. This includes cabinets and any other items that are wall mounted. Blocking shall span a minimum of three studs and be connected to each stud with a minimum of two screws.
- Refer to Mechanical and Electrical plans for equipment related to those disciplines. All required equipment not necessarily noted on this sheet.
- Room Signage: Provide signs adjacent to doors where indicated on interior elevations. Signs will be ADA compliant and the text will be that indicated on the Room Signage Schedule.
- Openings, pockets, etc. shall not be placed in slabs, beams, columns, walls, etc., unless specifically detailed on the drawings.
- Cap all open ends in structural steel components, typical.
- The exposed concrete floors will have all exposed construction and control joints sealed with a polyurethane sealant bead (backer rod where required).
- Provide a rubber-vinyl reducer or transition trim at all intersections of carpet and resilient tile, carpet and vinyl sheet goods, or at all edges of carpet that abut a raised or lowered surface of dissimilar material. Note: Provide replacement transitions or reducers only where removal of existing flooring is not required for transition of reducer trim replacement.
- Refer to the Site Plan for concrete stoops and walkways.
- Equipment is shown for reference only. Equipment to be provided by Owner and installed under separate contract.
- Kitchen equipment is Owner supplied and Contractor installed. Contractor is to provide rough-ins for Plumbing and Electrical. The Contractor shall also provide the Mechanical exhaust, exhaust hood and make-up air. The Contractor shall complete the final hookup and installation of the kitchen equipment as provided by the Owner. Coordinate exact locations of rough-ins with the owner's kitchen consultant prior to construction. See Food Service, Mechanical, Plumbing and Electrical Drawings.
- There should be no surface mounted conduit. All conduit to be concealed.
- See Code Analysis Plans, sheets G211, G212 and G213, for fire rated construction, rated enclosures, and occupancy classifications.
- The Contractor shall install one (1) recess mounted "Knob Box" #3270 (Black) #3273 (Aluminum) or surface mounted "Knob Box" #3261 (Black) #3263 (Aluminum) in an exterior wall location selected by the Owner and installed 6'-0" A.F.F. The Contractor shall include the cost of the "Knob Box" in his bid and shall acquire "Knob Box" in association with the local fire agency. Contractor shall include all labor for installation in his bid.
- Sand, grind, or patch (e) concrete floor as required to accommodate new construction. Install leveling compound as required. See Structural drawings for additional information.
- Where new gypsum board walls abut existing concrete scribe to fit tightly and caulk. Rated walls shall receive fire rated sealant where required to maintain rating.
- Repair and repaint the entire wall where alteration work is performed, U.N.O. Paint color to match (e) walls and areas adjacent.
- All touch up and new painting will be as follows:
Bottom coat: Latex primer
Intermediate coat and top coat: Acrylic Latex Enamel
Shen shall match existing adjacent surfaces. Contractor to coordinate paint manufacturer with Owner to match (e) maintenance paint stock.
- Texture all existing gypsum board walls to match texture of new walls where noted.
- Where plumbing fixtures are to be removed and no new fixture is to be installed, patch water supply hole with gypsum board, texture and paint to match wall. At waste opening, provide new chrome clean out cover plate with vandal resistant screw. Plate to be attached to cap inside chase. Provide interior sealant around perimeter of new cover plate.
- The Contractor shall clean all existing ceramic tile prior to installing any new fixtures and toilet partitions.
- Temporary construction walls and other measures must conform to Infection Prevention Measures as prescribed in Division 01 - General Requirements and reviewed with the VASNHC's Infection Control Risk Assessment (ICRA) team.
- All construction activities need to be coordinated with the schedule of operations of the areas adjacent to construction including any areas above or below that may be impacted.
- The contractor shall be responsible for coordinating support systems for medical equipment, to be supplied and installed by others. Due to the technical nature of the medical equipment, it is imperative the contractor request and obtain product information from the resident engineer prior to system rough-in. If the equipment to be installed differs in model, model or location from that shown on the construction drawings, the contractor shall notify the architect immediately. The rough-in work may not proceed until the architect and the design team has reviewed the MPPE systems, structural support and radiation shielding for compatibility with the construction drawings.

Wall Legend



Bid Documents - Final

Office of Construction and Facilities Management



Project Number
654-777

Building Number
1D

Drawing Number
AE125

Project Title
Remodel and Expansion of DICE Services

Location
975 Kirman Avenue, Reno, NV 89502


Date
4/4/2013

Checked
LM

Drawn
DG

Drawings Title
Second Floor Phase 2 Floor Plan

Approved: Project Director

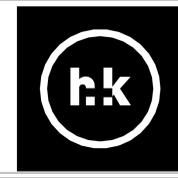

ARCHITECT/ENGINEERS:
H+K ARCHITECTS
5485 Reno Corporate Drive, Suite 100
Reno, Nevada 89511-2262
P 775-332-6640
F 775-332-6642
hkarchitects.com




CONSULTANTS:

Number	Revision	Date
3	Revision 3	7/22/13
4	Revision 4	8/5/13

1 Second Floor Phase 2 Plan

1/4" = 1'-0"

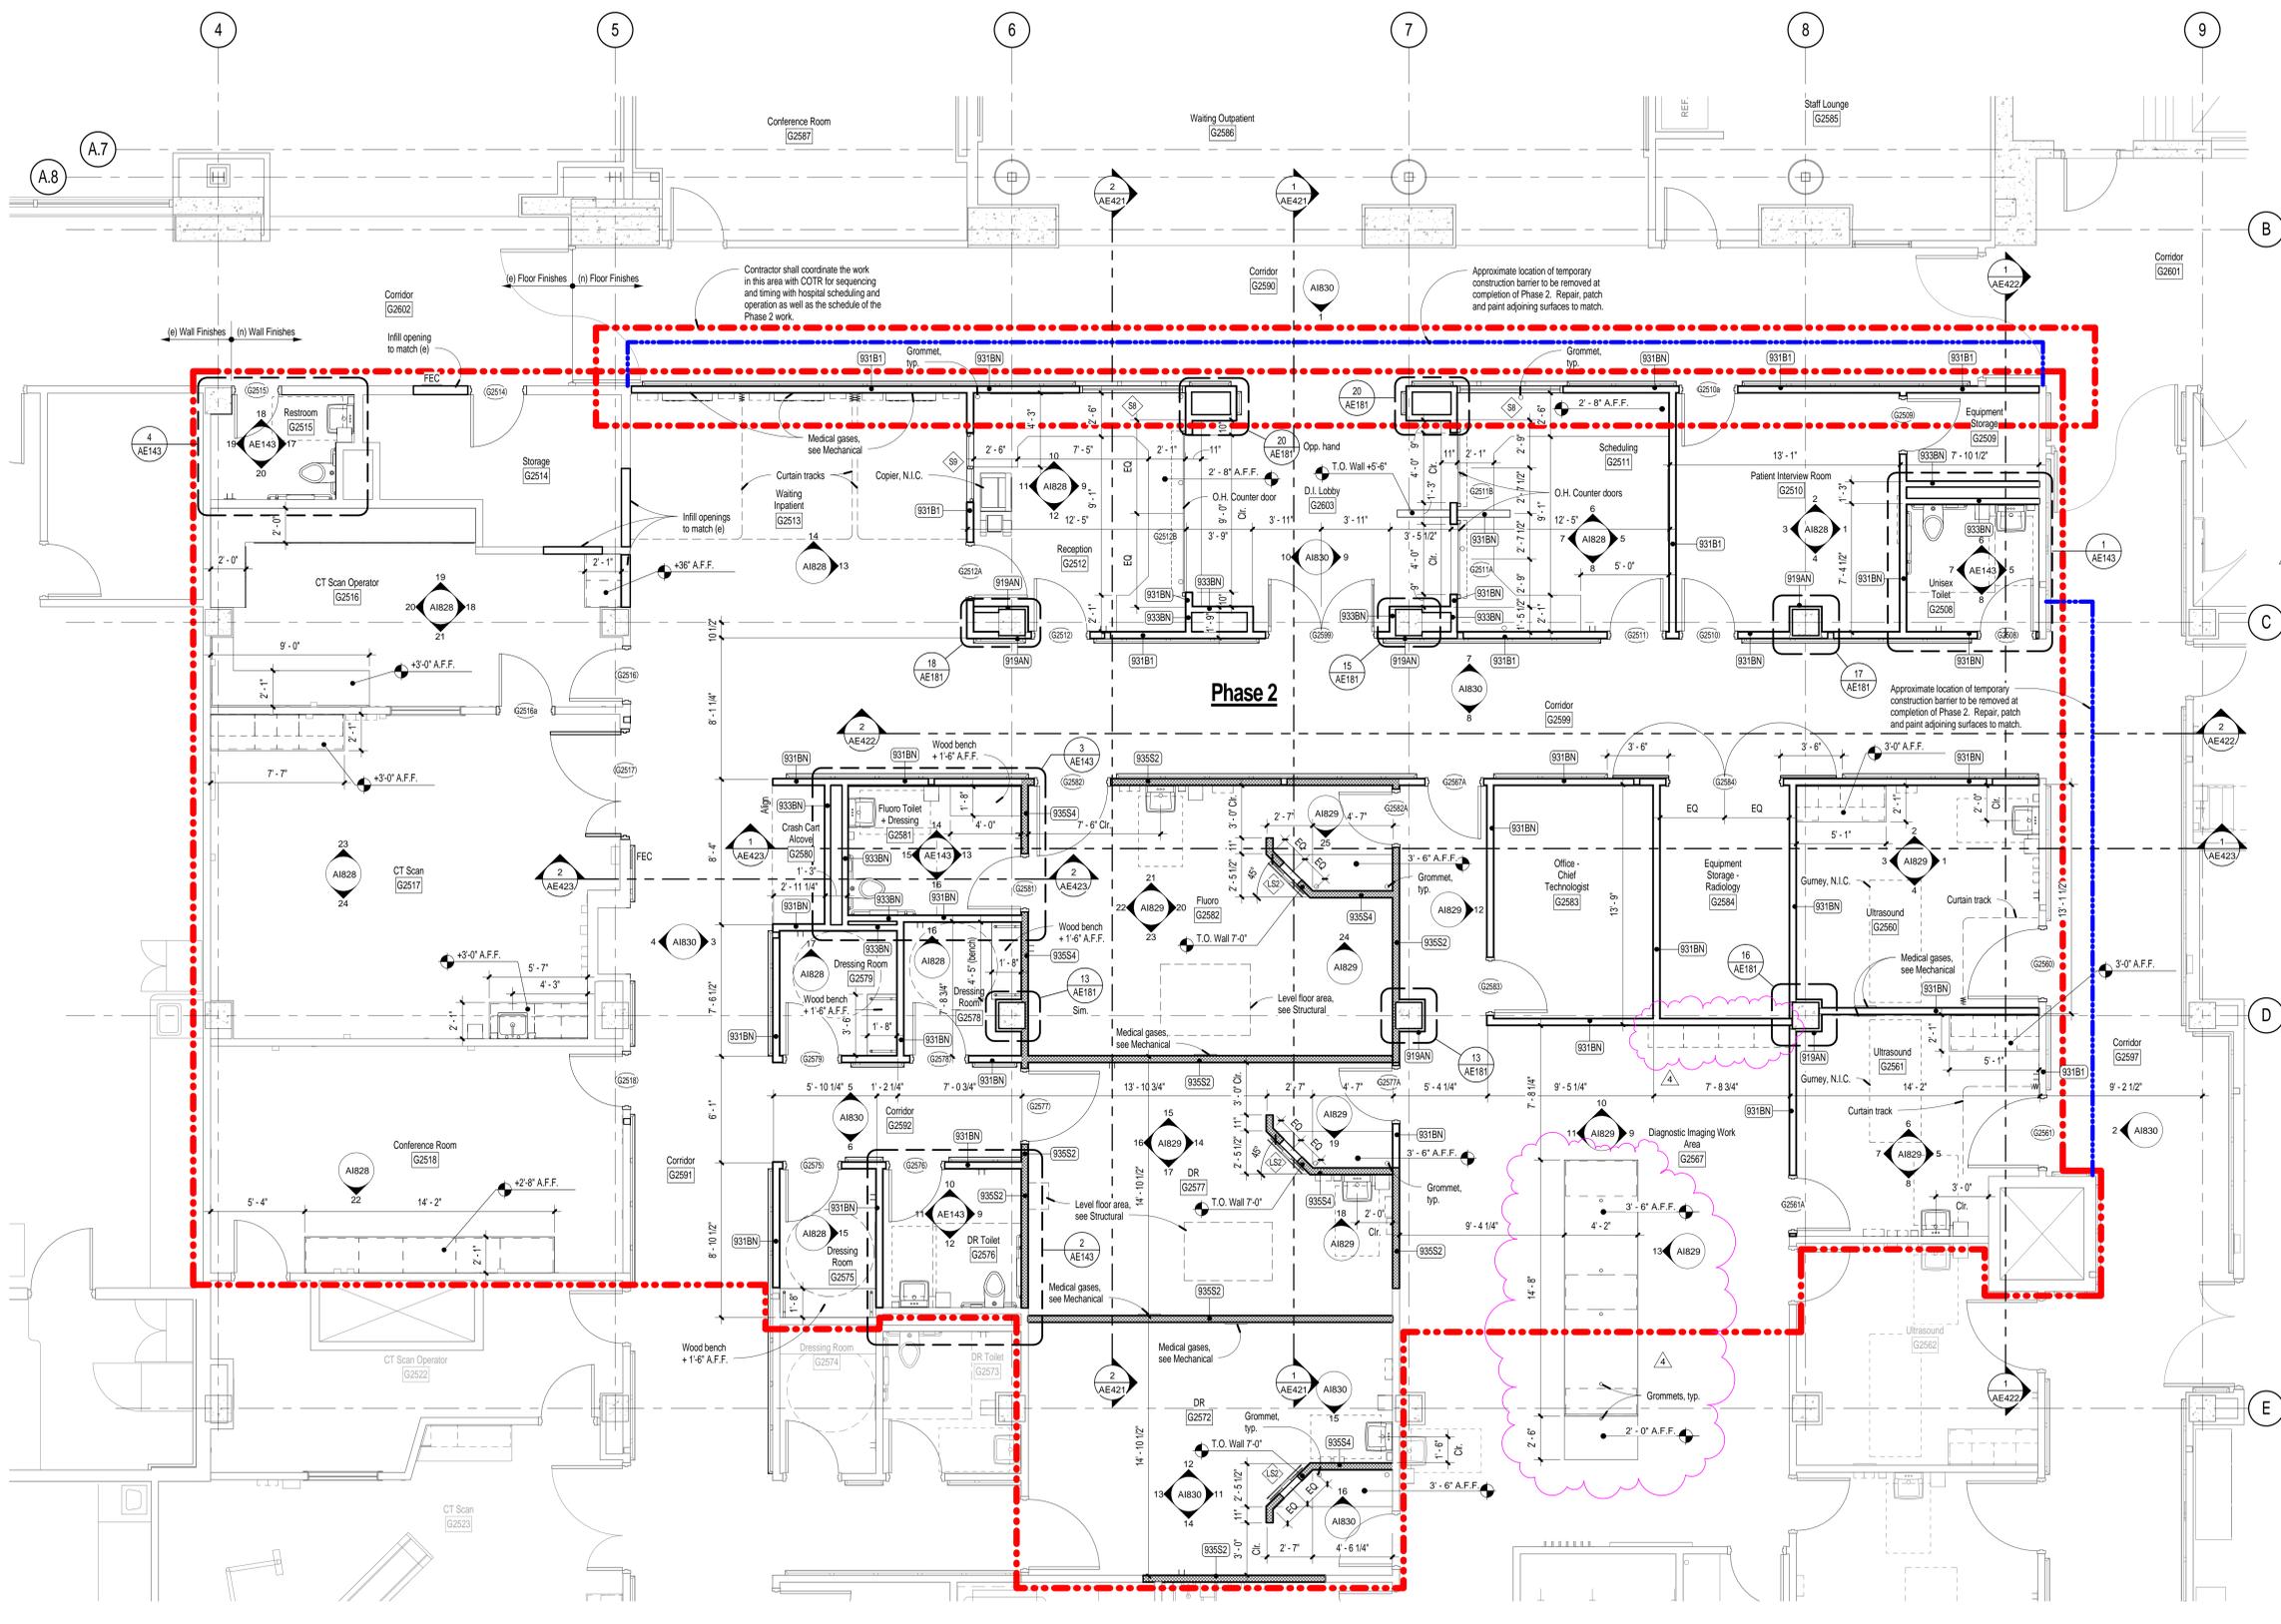

three eighths inch = one foot
 one eighth inch = one foot
 one quarter inch = one foot
 one half inch = one foot
 three quarters inch = one foot
 one inch = one foot
 one and one half inches = one foot
 two inches = one foot
 two and one half inches = one foot
 three inches = one foot
 three and one half inches = one foot
 four inches = one foot
 four and one half inches = one foot
 five inches = one foot
 five and one half inches = one foot
 six inches = one foot
 six and one half inches = one foot
 seven inches = one foot
 seven and one half inches = one foot
 eight inches = one foot
 eight and one half inches = one foot
 nine inches = one foot
 nine and one half inches = one foot
 ten inches = one foot
 ten and one half inches = one foot
 eleven inches = one foot
 eleven and one half inches = one foot
 twelve inches = one foot
 twelve and one half inches = one foot
 thirteen inches = one foot
 thirteen and one half inches = one foot
 fourteen inches = one foot
 fourteen and one half inches = one foot
 fifteen inches = one foot
 fifteen and one half inches = one foot
 sixteen inches = one foot
 sixteen and one half inches = one foot
 seventeen inches = one foot
 seventeen and one half inches = one foot
 eighteen inches = one foot
 eighteen and one half inches = one foot
 nineteen inches = one foot
 nineteen and one half inches = one foot
 twenty inches = one foot
 twenty and one half inches = one foot
 twenty one inches = one foot
 twenty one and one half inches = one foot
 twenty two inches = one foot
 twenty two and one half inches = one foot
 twenty three inches = one foot
 twenty three and one half inches = one foot
 twenty four inches = one foot
 twenty four and one half inches = one foot
 twenty five inches = one foot
 twenty five and one half inches = one foot
 twenty six inches = one foot
 twenty six and one half inches = one foot
 twenty seven inches = one foot
 twenty seven and one half inches = one foot
 twenty eight inches = one foot
 twenty eight and one half inches = one foot
 twenty nine inches = one foot
 twenty nine and one half inches = one foot
 thirty inches = one foot
 thirty and one half inches = one foot
 thirty one inches = one foot
 thirty one and one half inches = one foot
 thirty two inches = one foot
 thirty two and one half inches = one foot
 thirty three inches = one foot
 thirty three and one half inches = one foot
 thirty four inches = one foot
 thirty four and one half inches = one foot
 thirty five inches = one foot
 thirty five and one half inches = one foot
 thirty six inches = one foot
 thirty six and one half inches = one foot
 thirty seven inches = one foot
 thirty seven and one half inches = one foot
 thirty eight inches = one foot
 thirty eight and one half inches = one foot
 thirty nine inches = one foot
 thirty nine and one half inches = one foot
 forty inches = one foot
 forty and one half inches = one foot
 forty one inches = one foot
 forty one and one half inches = one foot
 forty two inches = one foot
 forty two and one half inches = one foot
 forty three inches = one foot
 forty three and one half inches = one foot
 forty four inches = one foot
 forty four and one half inches = one foot
 forty five inches = one foot
 forty five and one half inches = one foot
 forty six inches = one foot
 forty six and one half inches = one foot
 forty seven inches = one foot
 forty seven and one half inches = one foot
 forty eight inches = one foot
 forty eight and one half inches = one foot
 forty nine inches = one foot
 forty nine and one half inches = one foot
 fifty inches = one foot
 fifty and one half inches = one foot
 fifty one inches = one foot
 fifty one and one half inches = one foot
 fifty two inches = one foot
 fifty two and one half inches = one foot
 fifty three inches = one foot
 fifty three and one half inches = one foot
 fifty four inches = one foot
 fifty four and one half inches = one foot
 fifty five inches = one foot
 fifty five and one half inches = one foot
 fifty six inches = one foot
 fifty six and one half inches = one foot
 fifty seven inches = one foot
 fifty seven and one half inches = one foot
 fifty eight inches = one foot
 fifty eight and one half inches = one foot
 fifty nine inches = one foot
 fifty nine and one half inches = one foot
 sixty inches = one foot
 sixty and one half inches = one foot
 sixty one inches = one foot
 sixty one and one half inches = one foot
 sixty two inches = one foot
 sixty two and one half inches = one foot
 sixty three inches = one foot
 sixty three and one half inches = one foot
 sixty four inches = one foot
 sixty four and one half inches = one foot
 sixty five inches = one foot
 sixty five and one half inches = one foot
 sixty six inches = one foot
 sixty six and one half inches = one foot
 sixty seven inches = one foot
 sixty seven and one half inches = one foot
 sixty eight inches = one foot
 sixty eight and one half inches = one foot
 sixty nine inches = one foot
 sixty nine and one half inches = one foot
 seventy inches = one foot
 seventy and one half inches = one foot
 seventy one inches = one foot
 seventy one and one half inches = one foot
 seventy two inches = one foot
 seventy two and one half inches = one foot
 seventy three inches = one foot
 seventy three and one half inches = one foot
 seventy four inches = one foot
 seventy four and one half inches = one foot
 seventy five inches = one foot
 seventy five and one half inches = one foot
 seventy six inches = one foot
 seventy six and one half inches = one foot
 seventy seven inches = one foot
 seventy seven and one half inches = one foot
 seventy eight inches = one foot
 seventy eight and one half inches = one foot
 seventy nine inches = one foot
 seventy nine and one half inches = one foot
 eighty inches = one foot
 eighty and one half inches = one foot
 eighty one inches = one foot
 eighty one and one half inches = one foot
 eighty two inches = one foot
 eighty two and one half inches = one foot
 eighty three inches = one foot
 eighty three and one half inches = one foot
 eighty four inches = one foot
 eighty four and one half inches = one foot
 eighty five inches = one foot
 eighty five and one half inches = one foot
 eighty six inches = one foot
 eighty six and one half inches = one foot
 eighty seven inches = one foot
 eighty seven and one half inches = one foot
 eighty eight inches = one foot
 eighty eight and one half inches = one foot
 eighty nine inches = one foot
 eighty nine and one half inches = one foot
 ninety inches = one foot
 ninety and one half inches = one foot
 ninety one inches = one foot
 ninety one and one half inches = one foot
 ninety two inches = one foot
 ninety two and one half inches = one foot
 ninety three inches = one foot
 ninety three and one half inches = one foot
 ninety four inches = one foot
 ninety four and one half inches = one foot
 ninety five inches = one foot
 ninety five and one half inches = one foot
 ninety six inches = one foot
 ninety six and one half inches = one foot
 ninety seven inches = one foot
 ninety seven and one half inches = one foot
 ninety eight inches = one foot
 ninety eight and one half inches = one foot
 ninety nine inches = one foot
 ninety nine and one half inches = one foot
 one hundred inches = one foot
 one hundred and one half inches = one foot
 one hundred one inches = one foot
 one hundred one and one half inches = one foot
 one hundred two inches = one foot
 one hundred two and one half inches = one foot
 one hundred three inches = one foot
 one hundred three and one half inches = one foot
 one hundred four inches = one foot
 one hundred four and one half inches = one foot
 one hundred five inches = one foot
 one hundred five and one half inches = one foot
 one hundred six inches = one foot
 one hundred six and one half inches = one foot
 one hundred seven inches = one foot
 one hundred seven and one half inches = one foot
 one hundred eight inches = one foot
 one hundred eight and one half inches = one foot
 one hundred nine inches = one foot
 one hundred nine and one half inches = one foot
 one hundred ten inches = one foot
 one hundred ten and one half inches = one foot
 one hundred eleven inches = one foot
 one hundred eleven and one half inches = one foot
 one hundred twelve inches = one foot
 one hundred twelve and one half inches = one foot
 one hundred thirteen inches = one foot
 one hundred thirteen and one half inches = one foot
 one hundred fourteen inches = one foot
 one hundred fourteen and one half inches = one foot
 one hundred fifteen inches = one foot
 one hundred fifteen and one half inches = one foot
 one hundred sixteen inches = one foot
 one hundred sixteen and one half inches = one foot
 one hundred seventeen inches = one foot
 one hundred seventeen and one half inches = one foot
 one hundred eighteen inches = one foot
 one hundred eighteen and one half inches = one foot
 one hundred nineteen inches = one foot
 one hundred nineteen and one half inches = one foot
 one hundred twenty inches = one foot
 one hundred twenty and one half inches = one foot
 one hundred twenty one inches = one foot
 one hundred twenty one and one half inches = one foot
 one hundred twenty two inches = one foot
 one hundred twenty two and one half inches = one foot
 one hundred twenty three inches = one foot
 one hundred twenty three and one half inches = one foot
 one hundred twenty four inches = one foot
 one hundred twenty four and one half inches = one foot
 one hundred twenty five inches = one foot
 one hundred twenty five and one half inches = one foot
 one hundred twenty six inches = one foot
 one hundred twenty six and one half inches = one foot
 one hundred twenty seven inches = one foot
 one hundred twenty seven and one half inches = one foot
 one hundred twenty eight inches = one foot
 one hundred twenty eight and one half inches = one foot
 one hundred twenty nine inches = one foot
 one hundred twenty nine and one half inches = one foot
 one hundred thirty inches = one foot
 one hundred thirty and one half inches = one foot
 one hundred thirty one inches = one foot
 one hundred thirty one and one half inches = one foot
 one hundred thirty two inches = one foot
 one hundred thirty two and one half inches = one foot
 one hundred thirty three inches = one foot
 one hundred thirty three and one half inches = one foot
 one hundred thirty four inches = one foot
 one hundred thirty four and one half inches = one foot
 one hundred thirty five inches = one foot
 one hundred thirty five and one half inches = one foot
 one hundred thirty six inches = one foot
 one hundred thirty six and one half inches = one foot
 one hundred thirty seven inches = one foot
 one hundred thirty seven and one half inches = one foot
 one hundred thirty eight inches = one foot
 one hundred thirty eight and one half inches = one foot
 one hundred thirty nine inches = one foot
 one hundred thirty nine and one half inches = one foot
 one hundred forty inches = one foot
 one hundred forty and one half inches = one foot
 one hundred forty one inches = one foot
 one hundred forty one and one half inches = one foot
 one hundred forty two inches = one foot
 one hundred forty two and one half inches = one foot
 one hundred forty three inches = one foot
 one hundred forty three and one half inches = one foot
 one hundred forty four inches = one foot
 one hundred forty four and one half inches = one foot
 one hundred forty five inches = one foot
 one hundred forty five and one half inches = one foot
 one hundred forty six inches = one foot
 one hundred forty six and one half inches = one foot
 one hundred forty seven inches = one foot
 one hundred forty seven and one half inches = one foot
 one hundred forty eight inches = one foot
 one hundred forty eight and one half inches = one foot
 one hundred forty nine inches = one foot
 one hundred forty nine and one half inches = one foot
 one hundred fifty inches = one foot
 one hundred fifty and one half inches = one foot
 one hundred fifty one inches = one foot
 one hundred fifty one and one half inches = one foot
 one hundred fifty two inches = one foot
 one hundred fifty two and one half inches = one foot
 one hundred fifty three inches = one foot
 one hundred fifty three and one half inches = one foot
 one hundred fifty four inches = one foot
 one hundred fifty four and one half inches = one foot
 one hundred fifty five inches = one foot
 one hundred fifty five and one half inches = one foot
 one hundred fifty six inches = one foot
 one hundred fifty six and one half inches = one foot
 one hundred fifty seven inches = one foot
 one hundred fifty seven and one half inches = one foot
 one hundred fifty eight inches = one foot
 one hundred fifty eight and one half inches = one foot
 one hundred fifty nine inches = one foot
 one hundred fifty nine and one half inches = one foot
 one hundred sixty inches = one foot
 one hundred sixty and one half inches = one foot
 one hundred sixty one inches = one foot
 one hundred sixty one and one half inches = one foot
 one hundred sixty two inches = one foot
 one hundred sixty two and one half inches = one foot
 one hundred sixty three inches = one foot
 one hundred sixty three and one half inches = one foot
 one hundred sixty four inches = one foot
 one hundred sixty four and one half inches = one foot
 one hundred sixty five inches = one foot
 one hundred sixty five and one half inches = one foot
 one hundred sixty six inches = one foot
 one hundred sixty six and one half inches = one foot
 one hundred sixty seven inches = one foot
 one hundred sixty seven and one half inches = one foot
 one hundred sixty eight inches = one foot
 one hundred sixty eight and one half inches = one foot
 one hundred sixty nine inches = one foot
 one hundred sixty nine and one half inches = one foot
 one hundred seventy inches = one foot
 one hundred seventy and one half inches = one foot
 one hundred seventy one inches = one foot
 one hundred seventy one and one half inches = one foot
 one hundred seventy two inches = one foot
 one hundred seventy two and one half inches = one foot
 one hundred seventy three inches = one foot
 one hundred seventy three and one half inches = one foot
 one hundred seventy four inches = one foot
 one hundred seventy four and one half inches = one foot
 one hundred seventy five inches = one foot
 one hundred seventy five and one half inches = one foot
 one hundred seventy six inches = one foot
 one hundred seventy six and one half inches = one foot
 one hundred seventy seven inches = one foot
 one hundred seventy seven and one half inches = one foot
 one hundred seventy eight inches = one foot
 one hundred seventy eight and one half inches = one foot
 one hundred seventy nine inches = one foot
 one hundred seventy nine and one half inches = one foot
 one hundred eighty inches = one foot
 one hundred eighty and one half inches = one foot
 one hundred eighty one inches = one foot
 one hundred eighty one and one half inches = one foot
 one hundred eighty two inches = one foot
 one hundred eighty two and one half inches = one foot
 one hundred eighty three inches = one foot
 one hundred eighty three and one half inches = one foot
 one hundred eighty four inches = one foot
 one hundred eighty four and one half inches = one foot
 one hundred eighty five inches = one foot
 one hundred eighty five and one half inches = one foot
 one hundred eighty six inches = one foot
 one hundred eighty six and one half inches = one foot
 one hundred eighty seven inches = one foot
 one hundred eighty seven and one half inches = one foot
 one hundred eighty eight inches = one foot
 one hundred eighty eight and one half inches = one foot
 one hundred eighty nine inches = one foot
 one hundred eighty nine and one half inches = one foot
 one hundred ninety inches = one foot
 one hundred ninety and one half inches = one foot
 one hundred ninety one inches = one foot
 one hundred ninety one and one half inches = one foot
 one hundred ninety two inches = one foot
 one hundred ninety two and one half inches = one foot
 one hundred ninety three inches = one foot
 one hundred ninety three and one half inches = one foot
 one hundred ninety four inches = one foot
 one hundred ninety four and one half inches = one foot
 one hundred ninety five inches = one foot
 one hundred ninety five and one half inches = one foot
 one hundred ninety six inches = one foot
 one hundred ninety six and one half inches = one foot
 one hundred ninety seven inches = one foot
 one hundred ninety seven and one half inches = one foot
 one hundred ninety eight inches = one foot
 one hundred ninety eight and one half inches = one foot
 one hundred ninety nine inches = one foot
 one hundred ninety nine and one half inches = one foot
 two hundred inches = one foot
 two hundred and one half inches = one foot
 two hundred one inches = one foot
 two hundred one and one half inches = one foot
 two hundred two inches = one foot
 two hundred two and one half inches = one foot
 two hundred three inches = one foot
 two hundred three and one half inches = one foot
 two hundred four inches = one foot
 two hundred four and one half inches = one foot
 two hundred five inches = one foot
 two hundred five and one half inches = one foot
 two hundred six inches = one foot
 two hundred six and one half inches = one foot
 two hundred seven inches = one foot
 two hundred seven and one half inches = one foot
 two hundred eight inches = one foot
 two hundred eight and one half inches = one foot
 two hundred nine inches = one foot
 two hundred nine and one half inches = one foot
 two hundred ten inches = one foot
 two hundred ten and one half inches = one foot
 two hundred eleven inches = one foot
 two hundred eleven and one half inches = one foot
 two hundred twelve inches = one foot
 two hundred twelve and one half inches = one foot
 two hundred thirteen inches = one foot
 two hundred thirteen and one half inches = one foot
 two hundred fourteen inches = one foot
 two hundred fourteen and one half inches = one foot
 two hundred fifteen inches = one foot
 two hundred fifteen and one half inches = one foot
 two hundred sixteen inches = one foot
 two hundred sixteen and one half inches = one foot
 two hundred seventeen inches = one foot
 two hundred seventeen and one half inches = one foot
 two hundred eighteen inches = one foot
 two hundred eighteen and one half inches = one foot
 two hundred nineteen inches = one foot
 two hundred nineteen and one half inches = one foot
 two hundred twenty inches = one foot
 two hundred twenty and one half inches = one foot
 two hundred twenty one inches = one foot
 two hundred twenty one and one half inches = one foot
 two hundred twenty two inches = one foot
 two hundred twenty two and one half inches = one foot
 two hundred twenty three inches = one foot
 two hundred twenty three and one half inches = one foot
 two hundred twenty four inches = one foot
 two hundred twenty four and one half inches = one foot
 two hundred twenty five inches = one foot
 two hundred twenty five and one half inches = one foot
 two hundred twenty six inches = one foot
 two hundred twenty six and one half inches = one foot
 two hundred twenty seven inches = one foot
 two hundred twenty seven and one half inches = one foot
 two hundred twenty eight inches = one foot
 two hundred twenty eight and one half inches = one foot
 two hundred twenty nine inches = one foot
 two hundred twenty nine and one half inches = one foot
 two hundred thirty inches = one foot
 two hundred thirty and one half inches = one foot
 two hundred thirty one inches = one foot
 two hundred thirty one and one half inches = one foot
 two hundred thirty two inches = one foot
 two hundred thirty two and one half inches = one foot
 two hundred thirty three inches = one foot
 two hundred thirty three and one half inches = one foot
 two hundred thirty four inches = one foot
 two hundred thirty four and one half inches = one foot
 two hundred thirty five inches = one foot
 two hundred thirty five and one half inches = one foot
 two hundred thirty six inches = one foot
 two hundred thirty six and one half inches = one foot
 two hundred thirty seven inches = one foot
 two hundred thirty seven and one half inches = one foot
 two hundred thirty eight inches = one foot
 two hundred thirty eight and one half inches = one foot
 two hundred thirty nine inches = one foot
 two hundred thirty nine and one half inches = one foot
 two hundred forty inches = one foot
 two hundred forty and one half inches = one foot
 two hundred forty one inches = one foot
 two hundred forty one and one half inches = one foot
 two hundred forty two inches = one foot
 two hundred forty two and one half inches = one foot
 two hundred forty three inches = one foot
 two hundred forty three and one half inches = one foot
 two hundred forty four inches = one foot
 two hundred forty four and one half inches = one foot
 two hundred forty five inches = one foot
 two hundred forty five and one half inches = one foot
 two hundred forty six inches = one foot
 two hundred forty six and one half inches = one foot
 two hundred forty seven inches = one foot
 two hundred forty seven and one half inches = one foot
 two hundred forty eight inches = one foot
 two hundred forty eight and one half inches = one foot
 two hundred forty nine inches = one foot
 two hundred forty nine and one half inches = one foot
 two hundred fifty inches = one foot
 two hundred fifty and one half inches = one foot
 two hundred fifty one inches = one foot
 two hundred fifty one and one half inches = one foot
 two hundred fifty two inches = one foot
 two hundred fifty two and one half inches = one foot
 two hundred fifty three inches = one foot
 two hundred fifty three and one half inches = one foot
 two hundred fifty four inches = one foot
 two hundred fifty four and one half inches = one foot
 two hundred fifty five inches = one foot
 two hundred fifty five and one half inches = one foot
 two hundred fifty six inches = one foot
 two hundred fifty six and one half inches = one foot
 two hundred fifty seven inches = one foot
 two hundred fifty seven and one half inches = one foot
 two hundred fifty eight inches = one foot
 two hundred fifty eight and one half inches = one foot
 two hundred fifty nine inches = one foot
 two hundred fifty nine and one half inches = one foot
 two hundred sixty inches = one foot
 two hundred sixty and one half inches = one foot
 two hundred sixty one inches = one foot
 two hundred sixty one and one half inches = one foot
 two hundred sixty two inches = one foot
 two hundred sixty two and one half inches = one foot
 two hundred sixty three inches = one foot
 two hundred sixty three and one half inches = one foot
 two hundred sixty four inches = one foot
 two hundred sixty four and one half inches = one foot
 two hundred sixty five inches = one foot
 two hundred sixty five and one half inches = one foot
 two hundred sixty six inches = one foot
 two hundred sixty six and one half inches = one foot
 two hundred sixty seven inches = one foot
 two hundred sixty seven and one half inches = one foot
 two hundred sixty eight inches = one foot
 two hundred sixty eight and one half inches = one foot
 two hundred sixty nine inches = one foot
 two hundred sixty nine and one half inches = one foot
 two hundred seventy inches = one foot
 two hundred seventy and one half inches = one foot
 two hundred seventy one inches = one foot
 two hundred seventy one and one half inches = one foot
 two hundred seventy two inches = one foot
 two hundred seventy two and one half inches = one foot
 two hundred seventy three inches = one foot
 two hundred seventy three and one half inches = one foot
 two hundred seventy four inches = one foot
 two hundred seventy four and one half inches = one foot
 two hundred seventy five inches = one foot
 two hundred seventy five and one half inches = one foot
 two hundred seventy six inches = one foot
 two hundred seventy six and one half inches = one foot
 two hundred seventy seven inches = one foot
 two hundred seventy seven and one half inches = one foot
 two hundred seventy eight inches = one foot
 two hundred seventy eight and one half inches = one foot
 two hundred seventy nine inches = one foot
 two hundred seventy nine and one half inches = one foot
 two hundred eighty inches = one foot
 two hundred eighty and one half inches = one foot
 two hundred eighty one inches = one foot
 two hundred eighty one and one half inches = one foot
 two hundred eighty two inches = one foot
 two hundred eighty two and one half inches = one foot
 two hundred eighty three inches = one foot
 two hundred eighty three and one half inches = one foot
 two hundred eighty four inches = one foot
 two hundred eighty four and one half inches = one foot
 two hundred eighty five inches = one foot
 two hundred eighty five and one half inches = one foot
 two hundred eighty six inches = one foot
 two hundred eighty six and one half inches = one foot
 two hundred eighty seven inches = one foot
 two hundred eighty seven and one half inches = one foot
 two hundred eighty eight inches = one foot
 two hundred eighty eight and one half inches = one foot
 two hundred eighty nine inches = one foot
 two hundred eighty nine and one half inches = one foot
 two hundred ninety inches = one foot
 two hundred ninety and one half inches = one foot
 two hundred ninety one inches = one foot
 two hundred ninety one and one half inches = one foot
 two hundred ninety two inches = one foot
 two hundred ninety two and one half inches = one foot
 two hundred ninety three inches = one foot
 two hundred ninety three and one half inches = one foot
 two hundred ninety four inches = one foot
 two hundred ninety four and one half inches = one foot
 two hundred ninety five inches = one foot
 two hundred ninety five and one half inches = one foot
 two hundred ninety six inches = one foot
 two hundred ninety six and one half inches = one foot
 two hundred ninety seven inches = one foot
 two hundred ninety seven and one half inches = one foot
 two hundred ninety eight inches = one foot
 two hundred ninety eight and one half inches = one foot
 two hundred ninety nine inches = one foot
 two hundred ninety nine and one half inches = one foot
 three hundred inches = one foot
 three hundred and one half inches = one foot
 three hundred one inches = one foot
 three hundred one and one half inches = one foot
 three hundred two inches = one foot
 three hundred two and one half inches = one foot
 three hundred three inches = one foot
 three hundred three and one half inches = one foot
 three hundred four inches = one foot
 three hundred four and one half inches = one foot
 three hundred five inches = one foot
 three hundred five and one half inches = one foot
 three hundred six inches = one foot
 three hundred six and one half inches = one foot
 three hundred seven inches = one foot
 three hundred seven and one half inches = one foot
 three hundred eight inches = one foot
 three hundred eight and one half inches = one foot
 three hundred nine inches = one foot
 three hundred nine and one half inches = one foot
 three hundred ten inches = one foot
 three hundred ten and one half inches = one foot
 three hundred eleven inches = one foot
 three hundred eleven and one half inches = one foot
 three hundred twelve inches = one foot
 three hundred twelve and one half inches = one foot
 three hundred thirteen inches = one foot
 three hundred thirteen and one half inches = one foot
 three hundred fourteen inches = one foot
 three hundred fourteen and one half inches = one foot
 three hundred fifteen inches = one foot
 three hundred fifteen and one half inches = one foot
 three hundred sixteen inches = one foot
 three hundred sixteen and one half inches = one foot
 three hundred seventeen inches = one foot
 three hundred seventeen and one half inches = one foot
 three hundred eighteen inches = one foot
 three hundred eighteen and one half inches = one foot
 three hundred nineteen inches = one foot
 three hundred nineteen and one half inches = one foot
 three hundred twenty inches = one foot
 three hundred twenty and one half inches = one foot
 three hundred twenty one inches = one foot
 three hundred twenty one and one half inches = one foot
 three hundred twenty two inches = one foot
 three hundred twenty two and one half inches = one foot
 three hundred twenty three inches = one foot
 three hundred twenty three and one half inches = one foot
 three hundred twenty four inches = one foot
 three hundred twenty four and one half inches = one foot
 three hundred twenty five inches = one foot
 three hundred twenty five and one half inches = one foot
 three hundred twenty six inches = one foot
 three hundred twenty six and one half inches = one foot
 three hundred twenty seven inches = one foot
 three hundred twenty seven and one half inches = one foot
 three hundred twenty eight inches = one foot
 three hundred twenty eight and one half inches = one foot
 three hundred twenty nine inches = one foot
 three hundred twenty nine and one half inches = one foot
 three hundred thirty inches = one foot
 three hundred thirty and one half inches = one foot
 three hundred thirty one inches = one foot
 three hundred thirty one and one half inches = one foot
 three hundred thirty two inches = one foot
 three hundred thirty two and one half inches = one foot
 three hundred thirty three inches = one foot
 three hundred thirty three and one half inches = one foot
 three hundred thirty four inches = one foot
 three hundred thirty four and one half inches = one foot
 three hundred thirty five inches = one foot
 three hundred thirty five and one half inches = one foot
 three hundred thirty six inches = one foot
 three hundred thirty six and one half inches = one foot
 three hundred thirty seven inches = one foot
 three hundred thirty seven and one half inches = one foot
 three hundred thirty eight inches = one foot
 three hundred thirty eight and one half inches = one foot
 three hundred thirty nine inches = one foot
 three hundred thirty nine and one half inches = one foot
 three hundred forty inches = one foot
 three hundred forty and one half inches = one foot
 three hundred forty one inches = one foot
 three hundred forty one and one half inches = one foot
 three hundred forty two inches = one foot
 three hundred forty two and one half inches = one foot
 three hundred forty three inches = one foot
 three hundred forty three and one half inches = one foot
 three hundred forty four inches = one foot
 three hundred forty four and one half inches = one foot
 three hundred forty five inches = one foot
 three hundred forty five and one half inches = one foot
 three hundred forty six inches = one foot
 three hundred forty six and one half inches = one foot
 three hundred forty seven inches = one foot
 three hundred forty seven and one half inches = one foot
 three hundred forty eight inches = one foot
 three hundred forty eight and one half inches = one foot
 three hundred forty nine inches = one foot
 three hundred forty nine and one half inches = one foot
 three hundred fifty inches = one foot
 three hundred fifty and one half inches = one foot
 three hundred fifty one inches = one foot
 three hundred fifty one and one half inches = one foot
 three hundred fifty two inches = one foot
 three hundred fifty two and one half inches = one foot
 three hundred fifty three inches = one foot
 three hundred fifty three and one half inches = one foot
 three hundred fifty four inches = one foot
 three hundred fifty four and one half inches = one foot
 three hundred fifty five inches = one foot
 three hundred fifty five and one half inches = one foot
 three hundred fifty six inches = one foot
 three hundred fifty six and one half inches = one foot
 three hundred fifty seven inches = one foot
 three hundred fifty seven and one half inches = one foot
 three hundred fifty eight inches = one foot
 three hundred fifty eight and one half inches = one foot
 three hundred fifty nine inches = one foot
 three hundred fifty nine and one half inches = one foot
 three hundred sixty inches = one foot
 three hundred sixty and one half inches = one foot
 three hundred sixty one inches = one foot
 three hundred sixty one and one half inches = one foot
 three hundred sixty two inches = one foot
 three hundred sixty two and one half inches = one foot
 three hundred sixty three inches = one foot
 three hundred sixty three and one half inches = one foot
 three hundred sixty four inches = one foot
 three hundred sixty four and one half inches = one foot
 three hundred sixty five inches = one foot
 three hundred sixty five and one half inches = one foot
 three hundred sixty six inches = one foot
 three hundred sixty six and one half inches = one foot
 three hundred sixty seven inches = one foot
 three hundred sixty seven and one half inches = one foot
 three hundred sixty eight inches = one foot
 three hundred sixty eight and one half inches = one foot
 three hundred sixty nine inches = one foot
 three hundred sixty nine and one half inches = one foot
 three hundred seventy inches = one foot
 three hundred seventy and one half inches = one foot
 three hundred seventy one inches = one foot
 three hundred seventy one and one half inches = one foot
 three hundred seventy two inches = one foot
 three hundred seventy two and one half inches = one foot
 three hundred seventy three inches = one foot
 three hundred seventy three and one half inches = one foot
 three hundred seventy four inches = one foot
 three hundred seventy four and one half inches = one foot
 three hundred seventy five inches = one foot
 three hundred seventy five and one half inches = one foot
 three hundred seventy six inches = one foot
 three hundred seventy

three inches = one foot.
 one and one half inches = one foot.
 three quarters inch = one foot.
 one half inch = one foot.
 three eighths inch = one foot.
 one quarter inch = one foot.
 one eighth inch = one foot.
 8/20/13 10:31:52 AM CHH Local Project 0301030 VA DICE Local Drawn

31 CT Scan G2523 North
1/4" = 1'-0"

30 CT Scan G2523 East
1/4" = 1'-0"

29 Corridor G2598 South
1/4" = 1'-0"

28 Corridor G2598 West
1/4" = 1'-0"

27 Corridor G2598 East
1/4" = 1'-0"

26 Office - Staff Radiologist South
1/4" = 1'-0"

25 Office - Staff Radiologist East
1/4" = 1'-0"

24 Patient Prep G2544 West
1/4" = 1'-0"

23 Patient Prep G2544 South
1/4" = 1'-0"

22 Patient Prep G2544 East
1/4" = 1'-0"

21 Staff Lockers-Womens G2533 South
1/4" = 1'-0"

20 Staff Lockers-Womens G2533 West
1/4" = 1'-0"

19 Staff Lockers-Womens G2533 North
1/4" = 1'-0"

18 Staff Lockers-Womens G2533 East
1/4" = 1'-0"

17 Staff Lockers-Mens G2529 South
1/4" = 1'-0"

16 Staff Lockers-Mens G2529 West
1/4" = 1'-0"

15 Staff Lockers-Mens G2529 North
1/4" = 1'-0"

14 Staff Lockers-Mens G2529 East
1/4" = 1'-0"

13 IR Viewing/Consultation Room G2525 South
1/4" = 1'-0"

12 IR Viewing/Consultation Room G2525 West
1/4" = 1'-0"

11 IR Viewing/Consultation Room G2525 North
1/4" = 1'-0"

10 IR Viewing/Consultation Room G2525 East
1/4" = 1'-0"

9 IR Control Room G2540
1/4" = 1'-0"

8 IR Control Room G2540 South
1/4" = 1'-0"

7 IR Control Room G2540 West
1/4" = 1'-0"

6 IR Control Room G2540 North
1/4" = 1'-0"


5 IR Control Room G2540 East
1/4" = 1'-0"

4 TEE/Bronchoscopy G2545 South
1/4" = 1'-0"

3 TEE/Bronchoscopy G2545 West
1/4" = 1'-0"

2 TEE/Bronchoscopy G2545 North
1/4" = 1'-0"

1 TEE/Bronchoscopy G2545 East
1/4" = 1'-0"

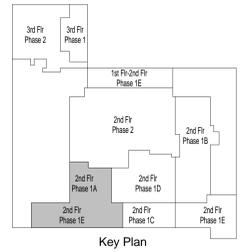

Number	Revision	Date
3	Revision 3	7/22/13
4	Revision 4	8/5/13

CONSULTANTS:



ARCHITECT/ENGINEERS:
H+K ARCHITECTS
 5485 Reno Corporate Drive, Suite 100
 Reno, Nevada 89511-2262
 P 775-332-6640
 F 775-332-6642
 hkarchitects.com



Drawings Title
Second Floor Phase 1A, 1C, 1E East & 1E West Interior Elevations

Approved: Project Director

Project Title
 Remodel and Expansion of
 DICE Services

Location
 975 Kirman Avenue, Reno, NV 89502

Date
 4/4/2013

Checked
 LM

Drawn
 DG

Project Number
 654-777


Building Number
 1D

Drawing Number
A1822


Office of
 Construction
 and Facilities
 Management

Department of
 Veterans Affairs


three inches = one foot.
 one and one half inches = one foot.
 one inch = one foot.
 three quarters inch = one foot.
 one half inch = one foot.
 three eighths inch = one foot.
 one quarter inch = one foot.
 one eighth inch = one foot.

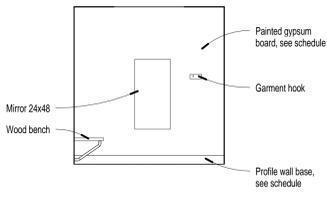


25 Dressing Room G2574 East
 1/4" = 1'-0"

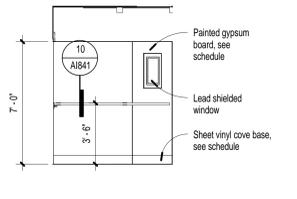


24 X-Ray, Chest and Skull Control G2568 South
 1/4" = 1'-0"

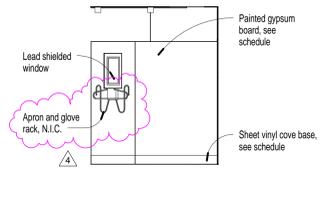


23 X-Ray, Chest and Skull G2568 Partial North
 1/4" = 1'-0"

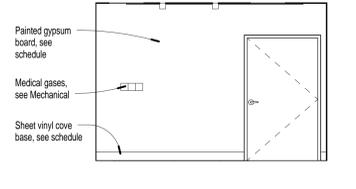


22 X-Ray, Chest and Skull G2568 South
 1/4" = 1'-0"

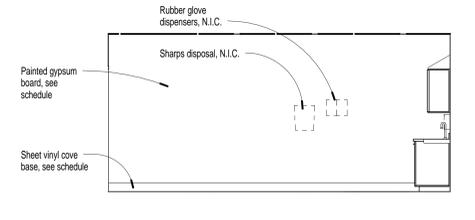


21 X-Ray, Chest and Skull G2568 West
 1/4" = 1'-0"

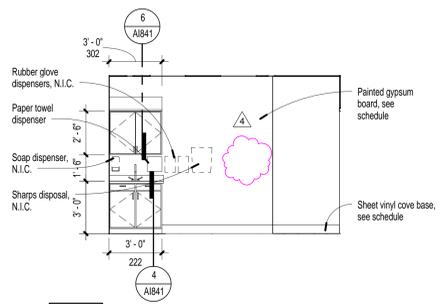


20 X-Ray, Chest and Skull G2568 North
 1/4" = 1'-0"

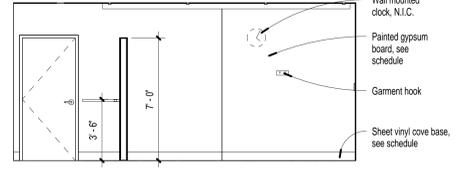


19 X-Ray, Chest and Skull G2568 East
 1/4" = 1'-0"

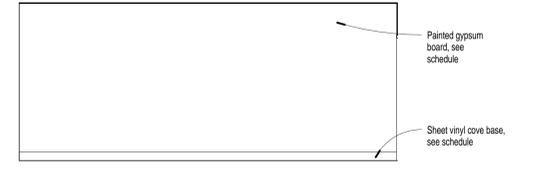


18 Diagnostic Imaging Work Area G2567 Partial East
 1/4" = 1'-0"

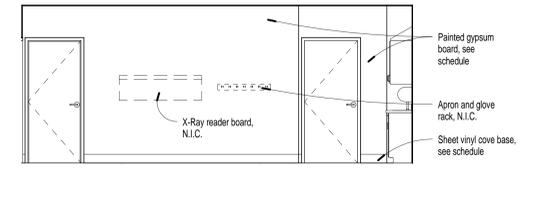


17 Diagnostic Imaging Work Area G2567 South
 1/4" = 1'-0"

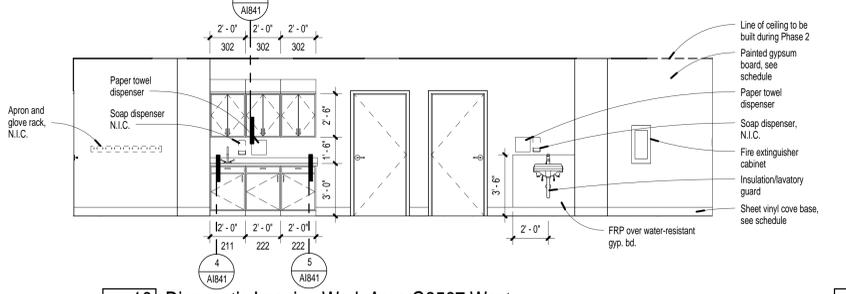


16 Diagnostic Imaging Work Area G2567 West
 1/4" = 1'-0"

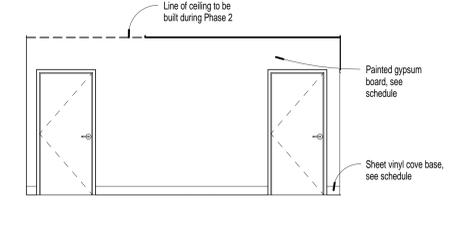


15 Diagnostic Imaging Work Area G2567 East
 1/4" = 1'-0"

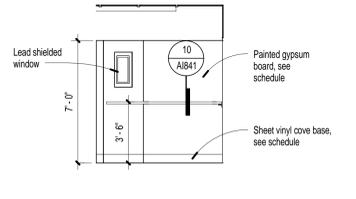


14 Fluoro Control G2566 West
 1/4" = 1'-0"

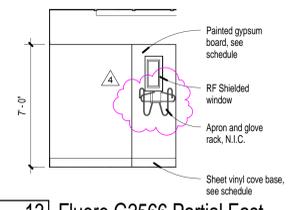


13 Fluoro G2566 Partial East
 1/4" = 1'-0"

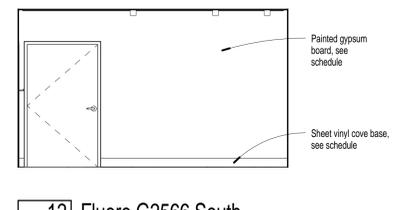


12 Fluoro G2566 South
 1/4" = 1'-0"

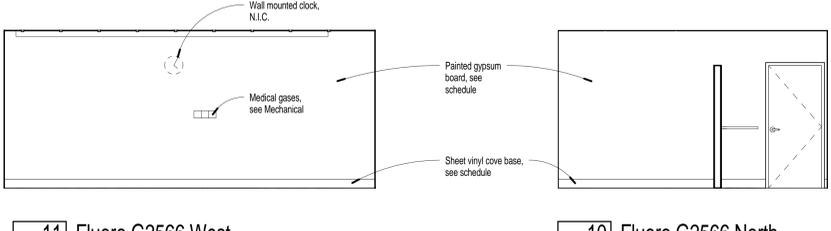


11 Fluoro G2566 West
 1/4" = 1'-0"

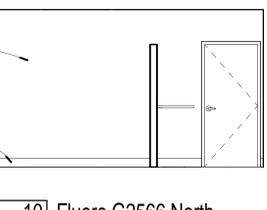


10 Fluoro G2566 North
 1/4" = 1'-0"

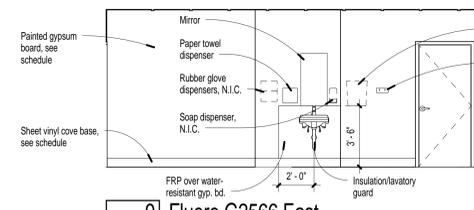


9 Fluoro G2566 East
 1/4" = 1'-0"

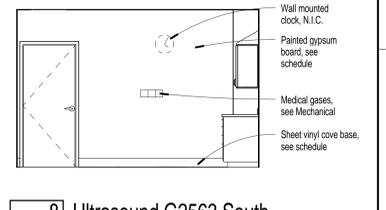


8 Ultrasound G2563 South
 1/4" = 1'-0"

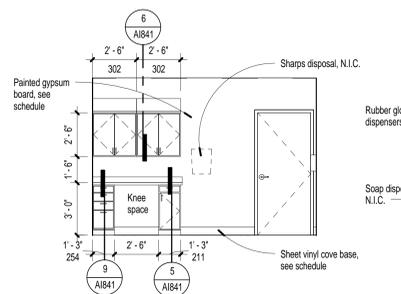


7 Ultrasound G2563 West
 1/4" = 1'-0"

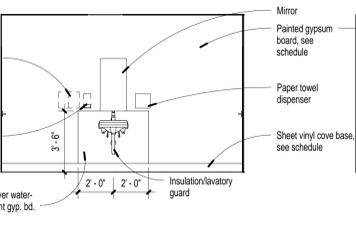


6 Ultrasound G2563 North
 1/4" = 1'-0"

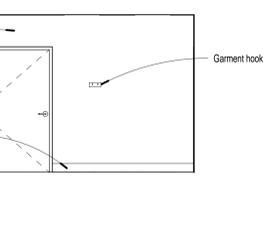


5 Ultrasound G2563 East
 1/4" = 1'-0"

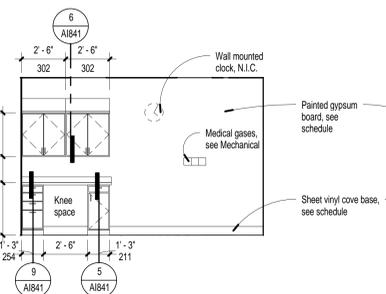


4 Ultrasound G2562 South
 1/4" = 1'-0"

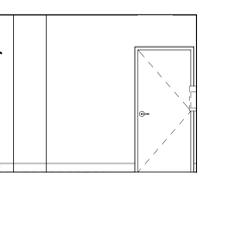


3 Ultrasound G2562 West
 1/4" = 1'-0"

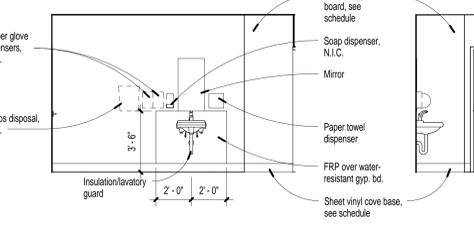

2 Ultrasound G2562 North
 1/4" = 1'-0"

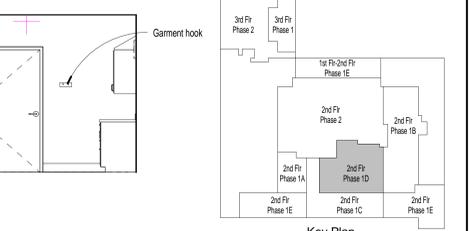

1 Ultrasound G2562 East
 1/4" = 1'-0"

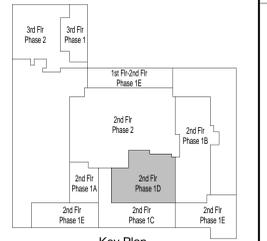

Key Plan

Number	Revision	Date
4	Revision 4	8/5/13

CONSULTANTS:



ARCHITECT/ENGINEERS:
H+K ARCHITECTS
 5485 Reno Corporate Drive, Suite 100
 Reno, Nevada 89511-2262
 P 775+332+6640
 F 775+332+6642
 hkarchitects.com



Drawings Title
Second Floor Phase 1D Interior Elevations
 Approved: Project Director







Project Title
 Remodel and Expansion of
 DICE Services
 Location
 975 Kirman Avenue, Reno, NV 89502
 Date
 4/4/2013
 Checked
 LM
 Drawn
 DG

Project Number
 654-777
 Building Number
 1D
 Drawing Number
A1825

Office of
 Construction
 and Facilities
 Management
 Department of
 Veterans Affairs

Bid Documents - Final

three inches = one foot.
 one and one half inches = one foot.
 one inch = one foot.
 three quarters inch = one foot.
 one half inch = one foot.
 three eighths inch = one foot.
 one quarter inch = one foot.
 one eighth inch = one foot.
 8/2013 10:28:59 AM CHH Local Project 03010302 VA DICE Local 08/13

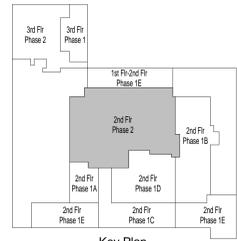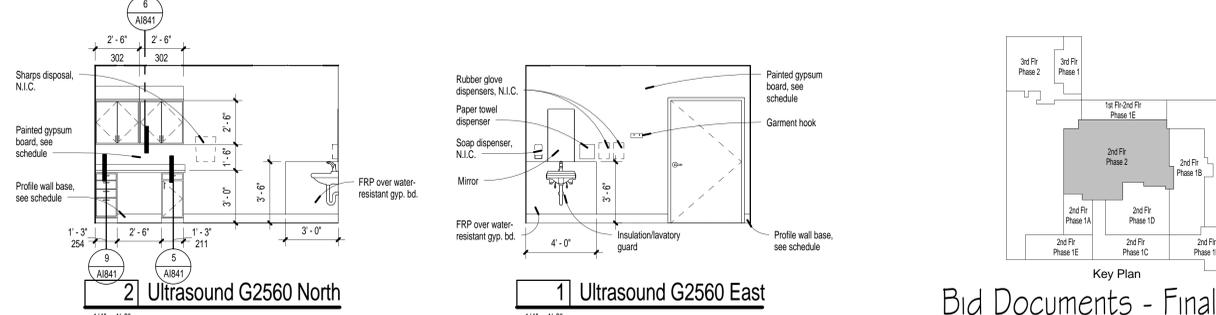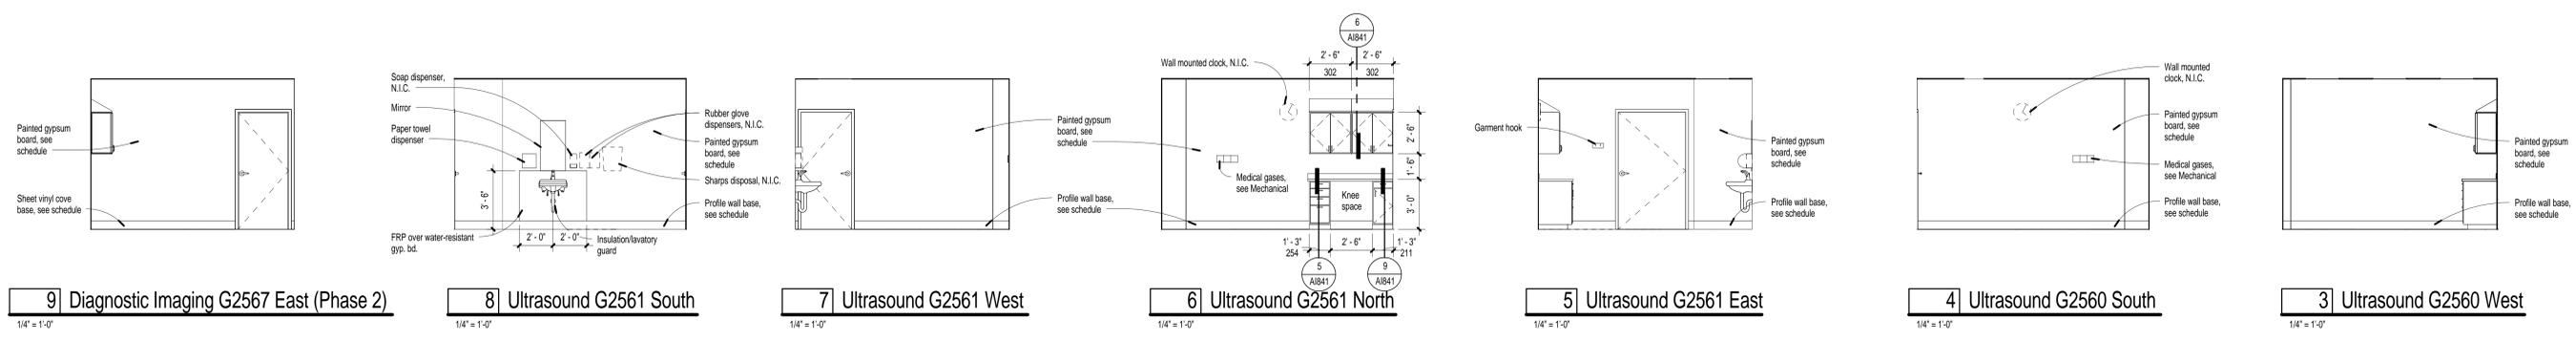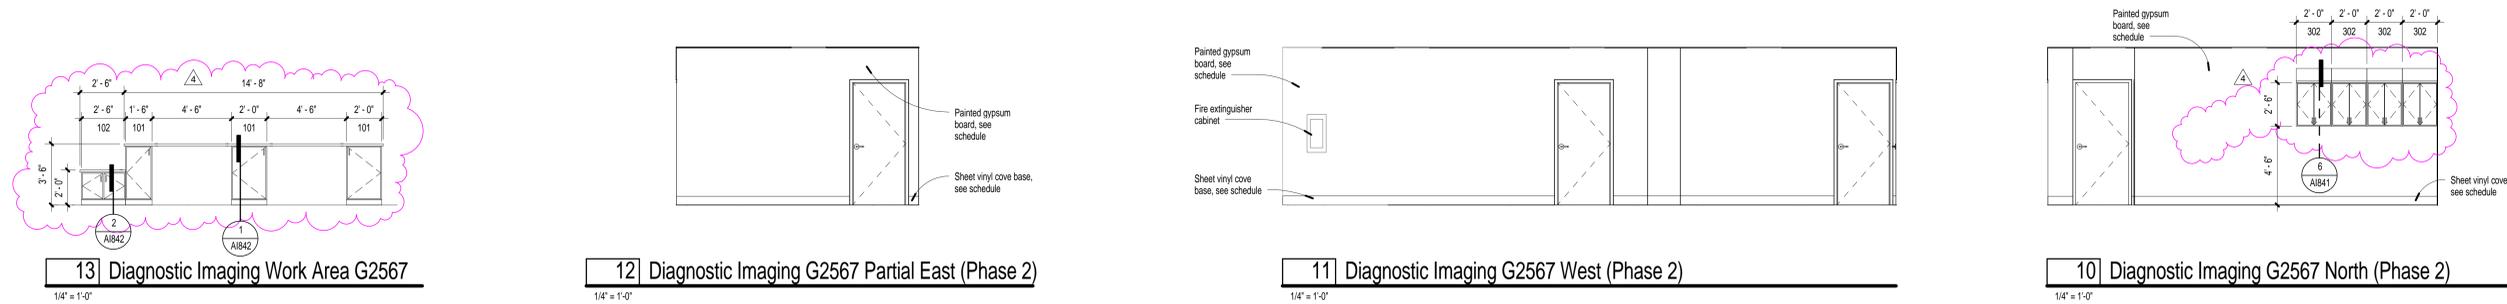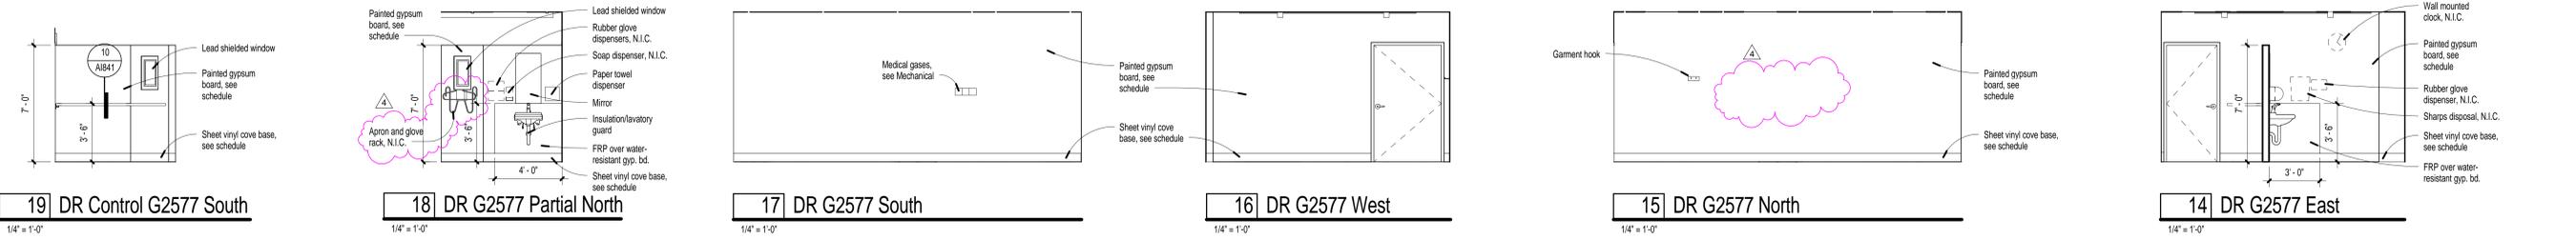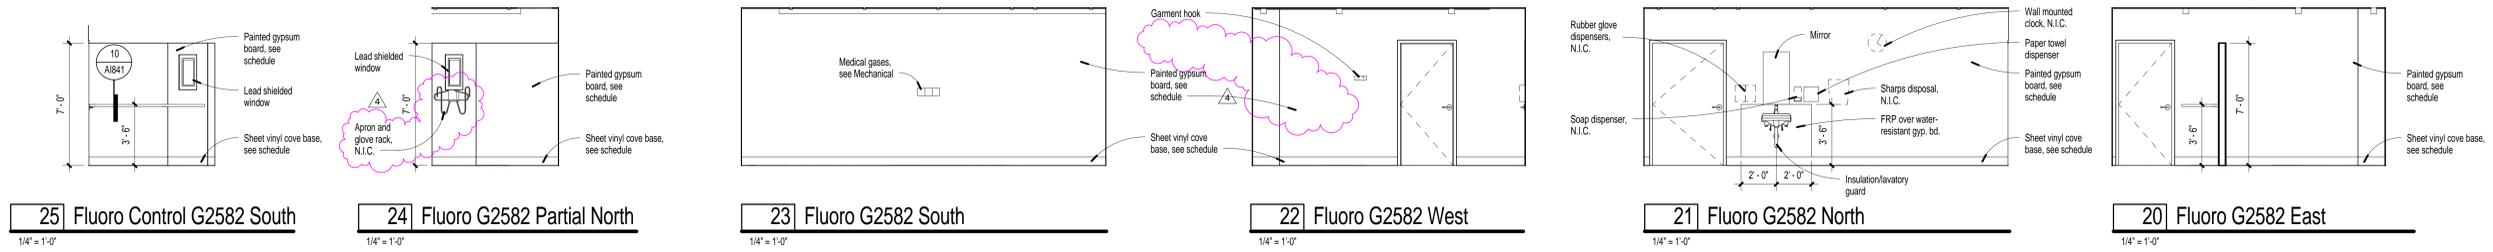

Number	Revision	Date
4	Revision 4	8/5/13

CONSULTANTS:



ARCHITECT/ENGINEERS:
H+K ARCHITECTS
 5485 Reno Corporate Drive, Suite 100
 Reno, Nevada 89511-2262
 P 775+332+6640
 F 775+332+6642
 hkarchitects.com



Drawings Title
Second Floor Phase 2 Interior Elevations
 Approved: Project Director


Project Title
 Remodel and Expansion of DICE Services
 Location
 975 Kirman Avenue, Reno, NV 89502
 Date
 4/4/2013
 Checked
 LM
 Drawn
 DG

Project Number
 654-777
 Building Number
 1D
 Drawing Number
A1829


Office of Construction and Facilities Management
 Department of Veterans Affairs

Bid Documents - Final


three inches = one foot.
 one and one half inches = one foot.
 one inch = one foot.
 three quarters inch = one foot.
 one half inch = one foot.
 three eighths inch = one foot.
 one quarter inch = one foot.
 one eighth inch = one foot.
 8/2013 10:28:09 AM CHH Local Project 0301030 VA DDC Local Dwg.rvt

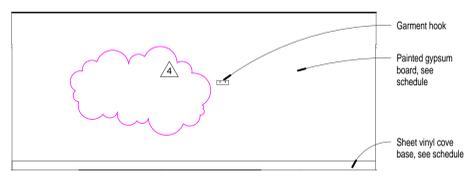


14 DR G2572 South
1/4" = 1'-0"

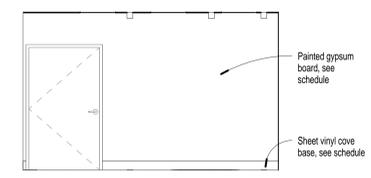


13 DR G2572 West
1/4" = 1'-0"

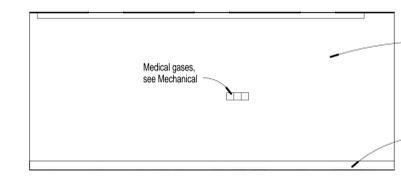


12 DR G2572 North
1/4" = 1'-0"

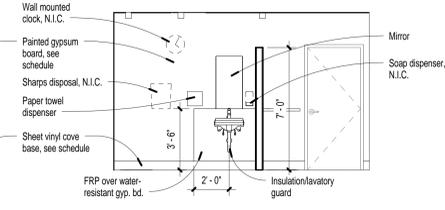


11 DR G2572 East
1/4" = 1'-0"

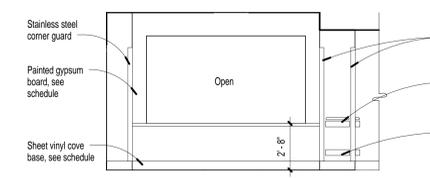


10 Corridor G2599 West at Door G2599
1/4" = 1'-0"

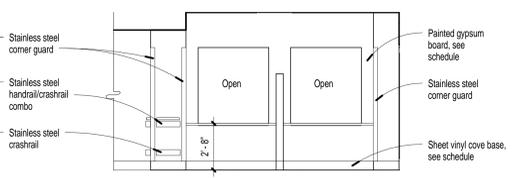


9 Corridor G2599 East at Door G2599
1/4" = 1'-0"

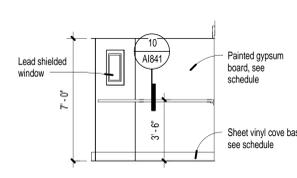


16 DR Control G2572 North
1/4" = 1'-0"

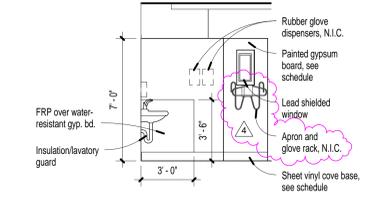


15 DR G2572 Partial South
1/4" = 1'-0"

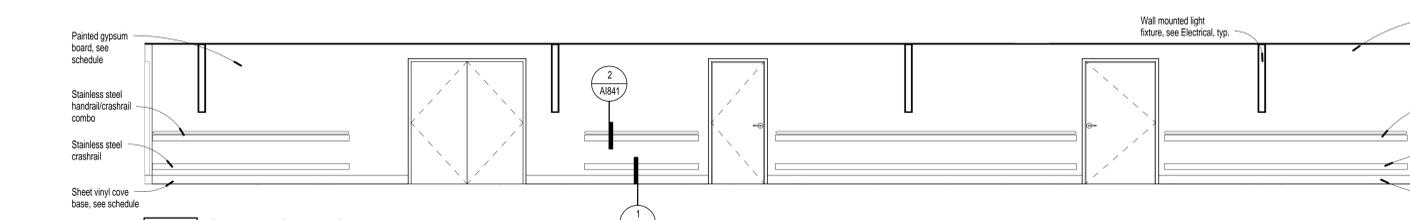


8 Corridor G2599 South
1/4" = 1'-0"

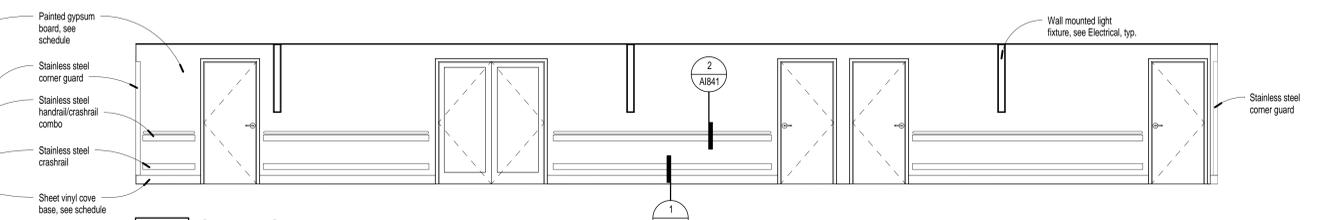


7 Corridor G2599 North
1/4" = 1'-0"

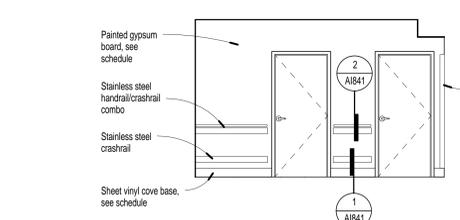


6 Corridor G2592 South
1/4" = 1'-0"

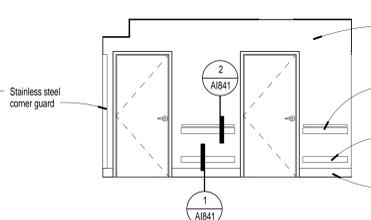


5 Corridor G2592 North
1/4" = 1'-0"

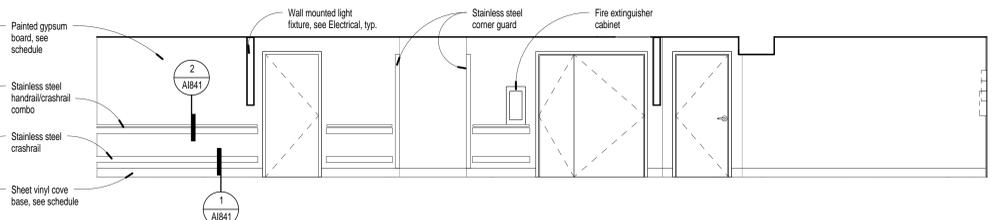


4 Corridor G2591 West (Phase 2)
1/4" = 1'-0"

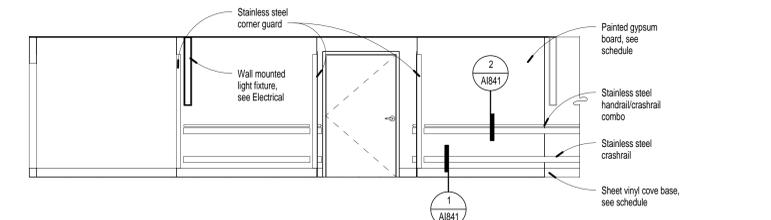


3 Corridor G2591 East (Phase 2)
1/4" = 1'-0"

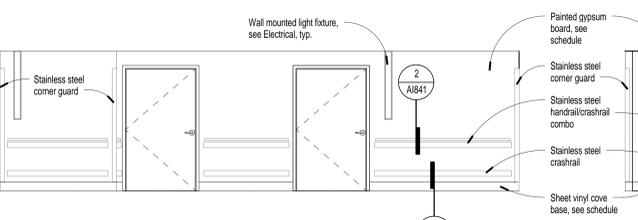

2 Corridor G2597 West (Phase 2)
1/4" = 1'-0"

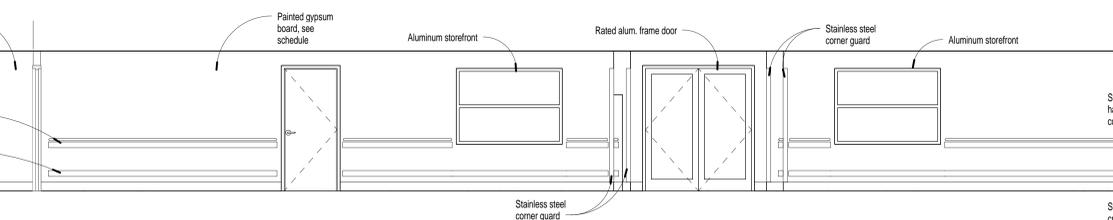

1 Corridor G2590 South
1/4" = 1'-0"

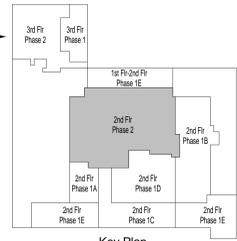

Key Plan

Number	Revision	Date
4	Revision 4	8/5/13

CONSULTANTS:



ARCHITECT/ENGINEERS:
H+K ARCHITECTS
 5485 Reno Corporate Drive, Suite 100
 Reno, Nevada 89511-2262
 P 775+332+6640
 F 775+332+6642
 hkarchitects.com



Drawings Title
Second Floor Phase 2 Interior Elevations
 Approved: Project Director

Project Title
 Remodel and Expansion of
 DICE Services
 Location
 975 Kirman Avenue, Reno, NV 89502
 Date
 4/4/2013
 Checked
 LM
 Drawn
 DG

Project Number
 654-777
 Building Number
 1D
 Drawing Number
A1830

Office of
 Construction
 and Facilities
 Management
 Department of
 Veterans Affairs

